

1 Design Criteria Plan (31,493 s.f.)  
1/16"=1'-0"

**DESIGN CRITERIA:**

Jonesboro, Arkansas  
 BUILDING CODES: 2008 I.B.C.  
 ELECTRICAL CODES: 2009 N.E.C.  
 PLUMBING CODES: 2008 A.P.C.  
 MECHANICAL CODES: 2003 A.M.C.  
 FIRE CODES: 2007 A.F.P.C. VOL. I, II, III  
 OCCUPANCY CLASSIFICATION: M-MERCANTILE  
 TYPE OF CONSTRUCTION: TYPE V B SPRINKLED

ALLOWABLE BUILDING HEIGHT: 40'-0"  
 ALLOWABLE BUILDING AREA: 9,000' S.F. (36,000 PER 508.1 INCREASE)  
 ALLOWABLE # OF STORIES: 1  
 ACTUAL BUILDING HEIGHT: 35'-0" APPROX.  
 ACTUAL BUILDING AREA: APPROX. 31,493 S.F.  
 ACTUAL # OF STORIES: 1

\* AREA INCREASE PER FORMULA BELOW (SECTION 508)

$A_n = A_1 + [A_2] + [A_3]$   
 $A_n = 9,000 + (9,000)(300)$   
 $A_n = 9,000 + 27,000$   
 $A_n = 36,000$

OCCUPANCY:  
 GROCERY:  
 ASSEMBLY (SEATING): 208/15 = 14  
 SALES: 20,089/30 = 670  
 OFFICES: 1,718/100 = 18  
 PREP AREAS: 2,293/200 = 11  
 ACCESSORY SPACES: 6,108/300 = 21  
 TOTAL OCCUPANCY: = 734

REQUIRED EXIT WIDTH OCCUPANCY (1.15 INCHES = 110 INCHES)  
 = 192 INCHES

PROVIDED EXIT WIDTH = 192 INCHES

NUMBER OF REMOTE EXITS = 4 (ONLY 3 REQUIRED PER TABLE 1019.1)  
 EXIT ACCESS TRAVEL DISTANCE = 250 FEET

REFER TO DESIGN CRITERIA FLOOR PLAN FOR OCCUPANCY AND EGRESS CALCULATIONS.

NOTE:  
 PER SECTION 508.3 A 20% INCREASE IS ALLOWED FOR BUILDING WITH AUTOMATIC SPRINKLER SYSTEM. PER 508 AREA MODIFICATION FORMULA INDICATED ABOVE.



NOTE:  
 ALL SUBCONTRACTORS SHALL BE RESPONSIBLE FOR REVIEWING ALL DRAWINGS IN THE SET PRIOR TO PLACING BID.


**PERMIT SET**

A New Grocery Facility for:  
**Harp's Food Stores (Store # \_\_\_\_\_)**  
 Corner of E. Highland Drive and Harrisburg Rd.  
 Jonesboro, Arkansas  
 © J. Price Architecture, Inc. 2011. All Rights Reserved



REVISIONS:

DESIGN CRITERIA PLAN  
 PROJECT: 102411  
 DATE: 11/07/2010  
 SHEET NUMBER: DC1

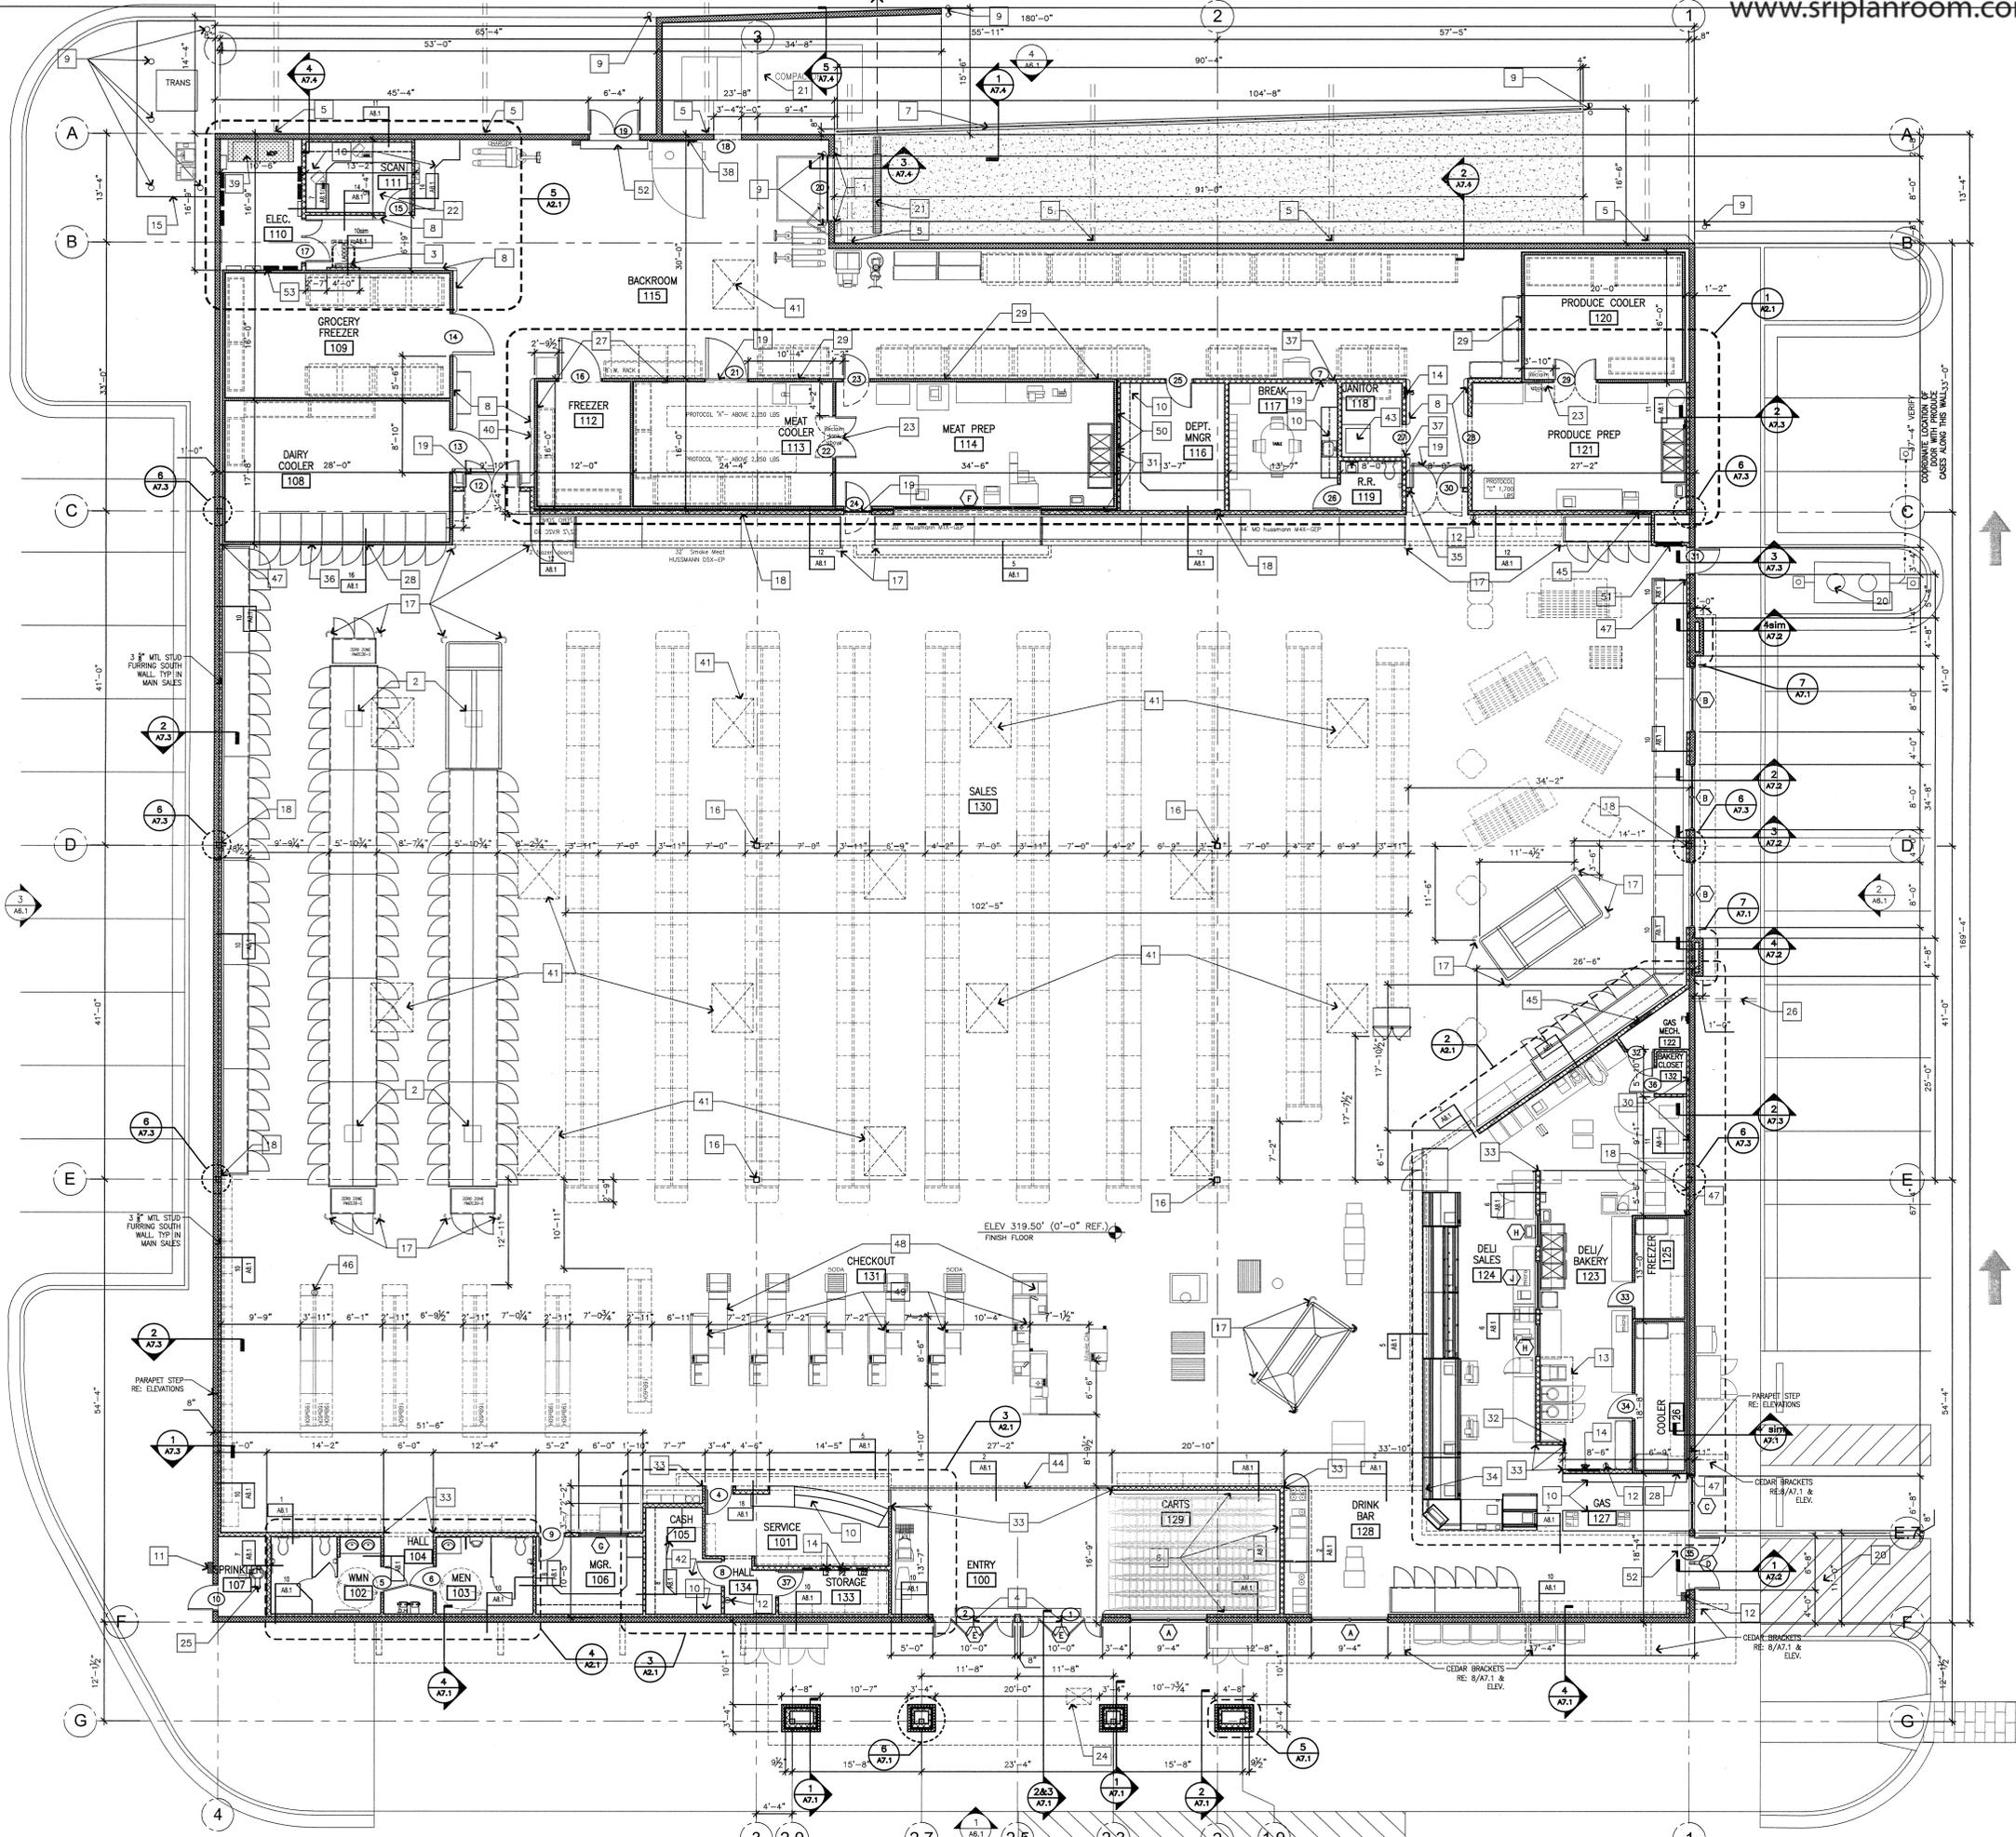

- GENERAL NOTES**
- REFER TO CIVIL ENGINEERING DRAWING FOR GRADING AT BUILDING PERIMETER AND SPOT ELEVATIONS AT SIDEWALKS AND CURBS. SPOT ELEVATIONS ON ARCHITECTURAL PLANS ARE SHOWN FOR BRIDGING PURPOSES. NOTIFY ARCHITECT OF DISCREPANCIES BETWEEN CIVIL AND ARCHITECTURAL DRAWINGS PRIOR TO BEGINNING WORK.
  - EQUIPMENT AND RACKING IS SHOWN FOR INFORMATION ONLY. REFER TO SHEET A2.1 AND MEP SHEETS FOR CONNECTION REQUIREMENTS ON OWNER PROVIDED AND INSTALLED ITEMS. COORDINATE INSTALLATION WITH OWNERS FORCES.
  - PAINT ALL EXPOSED STEEL COLUMNS AND CEILING STRUCTURE IN SALES AREA.
- KEYED NOTES**
- DOCK LEVELER, BUMPERS, PADS, RAIN HOOD, AND DOOR BY OWNER. INSTALLED BY G.C. RE: 3/4" AND 5/8" FOR SPECIFICATIONS.
  - PAINT EXPOSED RETROFIT PIPING TURNED DOWN TO CASES. MATCH ROOF STRUC. CEILING PAINT.
  - ROOF ACCESS LADDER AND PLATFORM ACCESS RE: 13/A10.1. PROVIDE AND INSTALL LATCH AT LADDER LOCATION. COORDINATE EXACT LADDER LOCATION WITH PROVIDED STRUCTURAL OPENING.
  - AUTOMATIC SLIDING DOOR PACKAGE WITH OPERATOR AND ACTUATING DEVICES.
  - RUN ROOF DOWNSPOUTS INTO UNDERGROUND COLLECTION SYSTEM. RE: CIVIL
  - POURED CONCRETE CURB RE: 8/A9.1
  - CONCRETE WALL WITH 36" OR 42" TALL STEEL PERAL. 42" REQUIRED FOR 30" OR MORE OF DROP. RE: CIVIL FOR GRADE ELEVATIONS. (PAINT RAL)
  - TREATED WOOD CURB RE: 8/A9.1
  - STEEL PIPE BRACKETS RE: 8/A10.1 (PAINT)
  - MILLWORK INSTALLED BY OWNER.
  - KNOX BOX. COORDINATE SIZE, LOCATION AND INSTALLATION W/ CITY.
  - WALL MOUNTED FIRE EXTINGUISHERS. PROVIDED AND INSTALLED BY OWNER. COORDINATE W/ FIRE MARSHAL TYPE, LOCATION, AND QUANTITY REQUIRED.
  - STAINLESS STEEL EXHAUST HOOD, REMECHANICAL, INSULATE OR CONSTRUCT GYPSUM CHASE AS REQUIRED TO MAINTAIN INDICATED FIRE RATING.
  - ELECTRICAL PANEL LOCATIONS RECESS IN 8" WALL WHERE THEY OCCUR IN STUD WALLS. RE: ELECTRICAL
  - CONSTRUCT TRANSFORMER AND GENERATOR PADS WITH LT. BROOM FINISH COORDINATE SIZES WITH EQUIPMENT REQUIREMENTS. RE: CIVIL FOR REINFORCEMENT
  - INSTALL STAINLESS STEEL COLUMN WRAPS (RE: 8/A9.1) TO 6"-0" A.F.F. ON ALL EXPOSED STEEL PIPE COLUMNS. PAINT ALL COLUMNS TO CEILING IN SALES FLOOR. COLUMNS HIDDEN FROM SHELVING DO NOT REQUIRE S.S. WRAP.
  - GENERAL CONTRACTOR TO INSTALL CORNER PROTECTORS SUPPLIED BY OWNER.
  - FLOOR STUD WALL TO FACE OF STEEL TUBE COLUMN TO ALLOW GIP TO PASS CLEANLY ACROSS FACE OF TUBE. (TYPICAL)
  - EXTEND POLISHED CONCRETE THROUGH DOORS TO BACKROOM AS SHOWN.
  - LOCATION OF UNDERGROUND GREASE TRAP. INSTALL MANHOLE COVERS LEVEL WITH NEW PAVING. RE: MEP, CIVIL
  - NEW TRENCH DRAIN SET IN PAVING DRAINED TO STORMWATER COLLECTION SYSTEM. RE: MECHANICAL AND CIVIL
  - INSTALL STUD JOIST CEILING WITH PLYWOOD DECKING FOR PLATFORM ABOVE SCAN ROOM. RE: STRUCTURAL FOR FRAMING
  - INSTALL WATER HEATERS ON TOP OF COOLER. RE: MEP
  - INSTALL RATED CEILING ACCESS PANEL EQUAL TO J.L. INDUSTRIES F2WB 24X36 FOR ACCESS TO SOFFIT AREA.
  - DOMESTIC AND FIRE WATER SERVICE LOCATION. COORDINATE SIZE AND LOCATION WITH MECHANICAL
  - STUD COUPLERS UNDER PAVING FOR GAS STATION ISLAND. COORDINATE CONSTRUCTION WITH OWNER PRIOR TO CONSTRUCTION.
  - G.C. SHALL PROVIDE AND INSTALL 1 1/2" O.D. 42" TALL GUARDRAIL W/ HORIZ. INTERMEDIATE RAIL AT 1'-8" ON TOP OF PLATFORM/COOLER WHERE EQUIPMENT IS LOCATED TYP. RE: 15/A8.1 (PAINT RAL)
  - ADHERE GYPSUM TO FACE OF COOLER.
  - SECURE 1/2"X 8" SHEETS OF PLYWOOD TO FACE OF ALL METAL COOLER PANELS IN BACKROOM. (TYPICAL)
  - FURR OUT BACK WALL IN DELI/BAKERY FOR ALL IN-WALL PIPING AND COND. RE: MECHANICAL
  - RUN PIPING FOR PLUMBING IN DELI PREP IN STUD CAVITY BEHIND WALL AND DRILL THRU COOLER PANELS. SEAL ALL PENETRATIONS.
  - 3"-0"X 7'-0" GYPSUM OPENING-TURN TILE BACK ON INSIDE FACE OF OPENING. (DEL)
  - 3/4" THK STAINLESS STEEL COVER AT ENDWALLS AND CORNERS TO 7'-0" A.F.F. LAP BACK 2" MIN. RE: 12/A9.1 FOR TYP DETAILS
  - PROVIDE DUPLEX ABOVE DELI HOT CASE FOR MENU BOARD. RE: ELECTRICAL
  - PARTITION WALL AT DOOR #30 TO THE BACKROOM SHALL EXTEND TO UNDERSIDE OF DUCTWORK. RE: MECHANICAL BRACE WALL AS REQ'D. RE: 7/A9.2 FOR JAMB CONDITION.
  - G.C. TO PROVIDE AND INSTALL STAINLESS STEEL KICKPLATE FROM FLOOR TO BOTTOM OF DAIRY COOLER DOORS.
  - FLUSH FRAME ONLY AT OPENING.
  - 36" SCH 40 PIPE ATTACHED TO WALL FOR HOLDING BAKING WIRE.
  - HATCHED AREA INDICATES LOCATION OF 6" BASED CONCRETE PAD FOR ELECTRICAL EQUIP. RE: MECHANICAL AND ELEC. FOR EXACT SIZE
  - ACCESS LADDER TO MEAT COOLER/FREEZER PROTOCOL UNITS. RE: 15/A8.1 SMA
  - SOCKETS WITH FALL GUARDS (PAINT GUARDS TO MATCH ROOF AND STRUCTURE)
  - CONSTRUCT SECURITY CASE OF EXPANDED METAL AND STEEL ANGLES OR METAL STUDS AT 16" O.C. ABOVE CEILING OVER THE CASH ROOM
  - CONC. FLOOR SINK W/ 24" TALL CONC. CURB. RE: 6/A3.1.
  - STAINLESS STEEL TRANSITION BETWEEN VCT AND CARPET IN VESTIBULE. RE: 5/A9.1
  - G.C. TO CONSTRUCT A FRAMED OPENING (8" TALL+ AND 2" CLEAR EA. SIDE) TO ACCOMMODATE REFRIGERATION PIPING IN STUD WALL FROM MECHANICAL ROOM TO DELI/BAKERY. COORDINATE WITH REFRIGERATION INSTALLER. RUN LINES BETWEEN JOISTS. RE: M.E.P. AND PLAN FOR LOCATION
  - PROVIDE DUPLEX ON TOP OF OWNER INSTALLED H.B.C. SHELVING. RE: ELEC
  - FLUSH COOLER/FREEZER TO WALL. MATCH WALL COLOR IN FINISHED AREAS TYP. (RE: DECOR FOR COLOR)
  - G.C. TO RECEIVE AND INSTALL CHECKSTANDS.
  - INSTALL CHECKSTAND POWER POLES. RE: ELEC
  - SET STUDS TO DEPARTMENT MANAGER ROOM 1" OFF OF MEAT PREP COOLER.
  - CONSTRUCT MECHANICAL CHASE FOR RETURN AIR. COORDINATE W/ MECHANICAL FOR LOWER SIZE REQUIRED AND PAINT LOWER TO MATCH WALL COLOR. RE: MECH
  - WALL MOUNTED AIR CURTAIN. COORDINATE POWER DROP IN STOREFRONT MULLION AT GAS ENTRY. RE: MECHANICAL/ELECTRICAL
  - MOUNT ELECTRICAL PANELS TO FREEZER WALLS. RE: ELECTRICAL

- PARTITION NOTES**
- ALL STUD AND CHANNEL SPACING SHALL BE 16" UNLESS NOTED OTHERWISE.
  - STUDS OVER 14'-0" TALL SHALL BE 20 GA.
  - LOCATE BRACING ON INTERIOR SIDE OF ROOM IN A CONCEALED MANNER.
  - WATER RESISTANT GYPSUM SHALL BE USED IN "WET" AREAS (TOILETS, FOOD PREP AREAS, ETC.)
  - BRACE TO ADJACENT WALLS WITH METAL STUDS WHERE POSSIBLE.
  - ALL DIMENSIONS ARE TO FACE OF METAL STUD UNO.
  - MAXIMUM LENGTH OF UNBRACED WALL SHALL BE 8'-0".
  - REFER TO ROOM FINISH SCHEDULE FOR WALL FINISH MATERIALS.
  - INSTALL GYPSUM CONTROL JOINTS IN WALLS OVER 30' IN LENGTH. RE: 15/A8.1 COORDINATE CONTROL JOINT LOCATIONS W/ ARCHITECT IN FIELD.

1 Architectural Floor Plan (31,493 Sq. Ft. Approx.)

1/8"=1'-0"




NOTE: ALL SUBCONTRACTORS SHALL BE RESPONSIBLE FOR REVIEWING ALL DRAWINGS IN THE SET PRIOR TO PLACING BID.

PERMIT SET  
A New Grocery Facility for:  
**Harp's Food Stores (Store # )**  
Corner of E. Highland Drive and Harrisburg Rd.  
Jonesboro, Arkansas  
© J. Price Architecture, Inc. 2011. All Rights Reserved



REVISIONS:

FLOOR PLAN  
DATE: FEBRUARY 02, 2010  
PROJECT: 10-0411  
SHEET NUMBER: **A1.1**

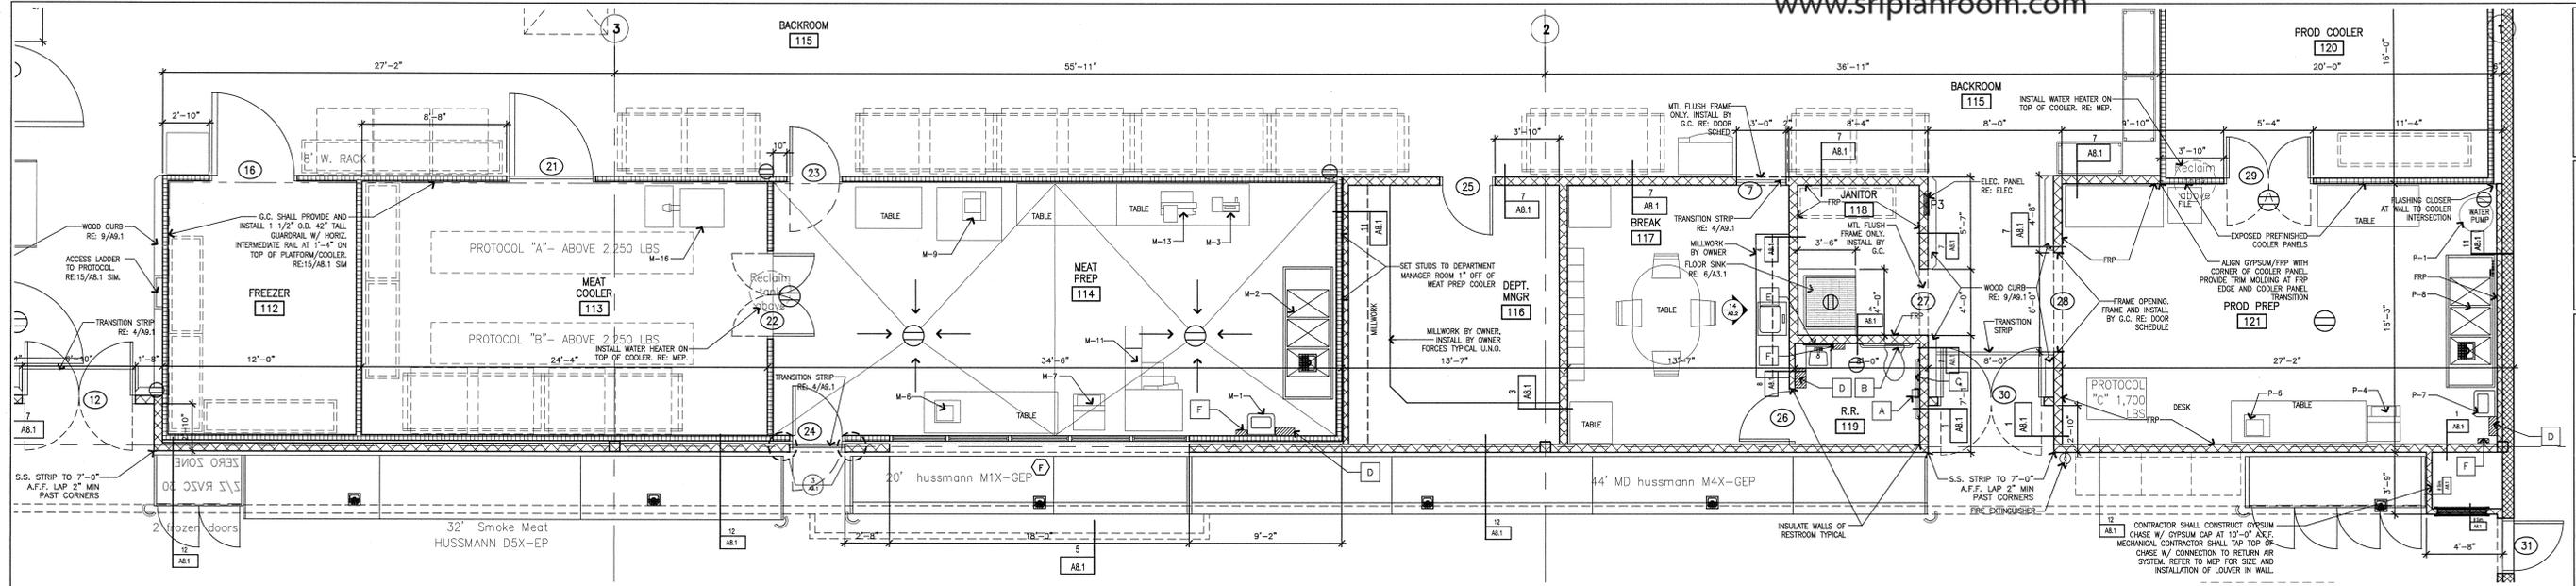

1 Enlarged Floor Plan  
SCALE: 1/4" = 1'-0"

ITEM MARK	DESCRIPTION	FURNISHED BY		INSTALLED BY		FINAL CONNECTION		REMARKS
		OWNER	G.C.	OWNER	G.C.	G.C./P-PLUM	G.C./E-ELECT	
B-03	GLAZER	X	-	X	-	-	-	
B-05	DOUBLE RACK OVEN (GAS)	X	-	X	-	G/P	-	E/P
B-06	PROOFER	X	-	X	-	X	-	E/P
B-07	HANDSINK	X	-	-	-	P	-	P
B-08	3-COMP SINK	X	-	-	-	P	-	P
B-13	FRYERS	X	-	-	-	E/G	-	E
B-14	2 DOOR REFRIGERATOR	X	-	-	-	G/E	-	E
B-15	BREADING STATION	X	-	X	-	X	-	-
B-22	CHICKEN ROTISSERIE	X	-	-	-	G/E/P	-	E
B-23	*NOT USED*	X	-	X	-	X	-	-
B-24	AUTO-SLICER	X	-	X	-	X	-	-
B-25	MANUAL-SLICER	X	-	X	-	X	-	-
B-26	TABLE TOP WRAPPER	X	-	X	-	X	-	-
B-27	BREAD SLICER	X	-	X	-	X	-	-
B-28	SERVICE SCALE/PRINTER	X	-	X	-	X	-	-
B-31	TABLE TOP WRAPPER	X	-	X	-	X	-	-
B-32	20 QT. A200 MIXER	X	-	X	-	X	-	E
B-34	SERVICE SCALE/PRINTER	X	-	X	-	X	-	-
B-35	SERVICE SCALE/PRINTER	X	-	X	-	X	-	-
B-36	80 QT. MIXER	X	-	X	-	-	-	E


ITEM MARK	DESCRIPTION	FURNISHED BY		INSTALLED BY		FINAL CONNECTION		REMARKS
		OWNER	G.C.	OWNER	G.C.	G.C./P-PLUM	G.C./E-ELECT	
M-1	HAND SINK	X	-	-	-	P	-	X P
M-2	3 COMP. SINK	X	-	-	-	P/E	-	- P/E
M-3	TENDERIZER	X	-	X	-	X	-	-
M-6	SERVICE SCALE/PRINTER	X	-	X	-	X	-	-
M-7	3 ROLL WRAPPER	X	-	X	-	X	-	-
M-9	MEAT SAW	X	-	X	-	X	-	E
M-11	WRAPPER (AUTOMATIC)	X	-	X	-	X	-	E
M-13	SLICER	X	-	X	-	X	-	-
M-16	MIXER/GRINDER	X	-	X	-	-	-	E
M-17	SERVICE SCALE/PRINTER	X	-	X	-	X	-	-

ITEM MARK	DESCRIPTION	FURNISHED BY		INSTALLED BY		FINAL CONNECTION		REMARKS
		OWNER	G.C.	OWNER	G.C.	G.C./P-PLUM	G.C./E-ELECT	
P-1	WATER PUMP	X	-	X	-	G/P/E	-	X E/P
P-2	PRODUCE DESK	X	-	X	-	X	-	-
P-4	WRAPPER	X	-	X	-	X	-	-
P-6	SERVICE SCALE/PRINTER	X	-	X	-	X	-	-
P-7	HAND SINK	X	-	-	-	P	-	P
P-8	3 COMP. SINK	X	-	-	-	P	-	P


NOTE: G.C. TO RECEIVE AND INSPECT ALL EQUIPMENT FOR DAMAGE. CONTRACTOR WILL BE REQUIRED TO UNLOAD AND PLACE IN STORE VARIOUS OTHER EQUIPMENT ITEMS. CONTRACTOR WILL NOT NEED TO UNCRATE OR PUT IN FINAL PLACE ITEMS SUCH AS TABLES, CHAIRS, FURNITURE, RACKING, ETC...

KEY	FIXTURE DESCRIPTION	MANUF. & MODEL #	FINISH
[A]	TOILET PAPER DISPENSER	PROVIDED BY OWNER AND INSTALLED BY G.C.	STAINLESS STEEL
[B]	36" GRAB BAR	BOBROCK B-6206.99 X 36 INCH 2"-10" A.F.F. AND 4" OFF WALL	STAINLESS STEEL
[C]	42" GRAB BAR	BOBROCK B-6208.99 X 42 INCH 2"-10" A.F.F. AND 12" OFF WALL	STAINLESS STEEL
[D]	PAPER TOWEL DISPENSER	PROVIDED BY OWNER AND INSTALLED BY G.C.	STAINLESS STEEL
[E]	VANITY MIRROR	FRAMED MIRROR (DE: DECOR) A.F.F. (ONE PER LAVATORY)	RE: DECOR/ MIRROR GLASS
[F]	SOAP DISPENSER	PROVIDED BY OWNER AND INSTALLED BY G.C.	PLASTIC
[G]	ADA SIGNAGE	BY OWNER INSTALLED BY G.C.	PLASTIC
[H]	DIAPER CHANGING STATION	DIAPER DECK BY AMERICAN INFANT CARE PRODUCTS 3'-0" A.F.F. TO OPEN DECK	HIGH DENSITY POLYETHYLENE
[J]	18" VERTICAL GRAB BAR	GRAB BARS - 18" BOBROCK B-6106 X18" VERTICAL 3'-4" FROM WALL AND 3'-4" TO BOTTOM OF BAR.	STAINLESS STEEL


- NOTES:  
1. INSTALL PIPE PROTECTION SLEEVES IN ALL LAVATORY PIPING BELOW  
2. PROVIDE 2 DIAPER DECKS. RE: PLAN

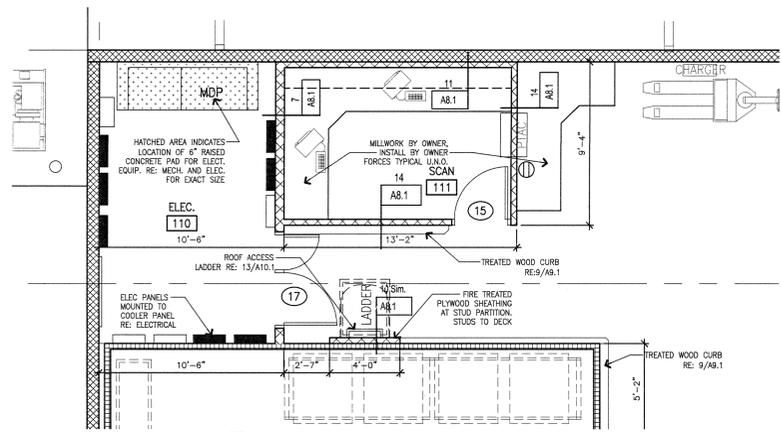


5 Enlarged Floor Plan  
SCALE: 1/4" = 1'-0"

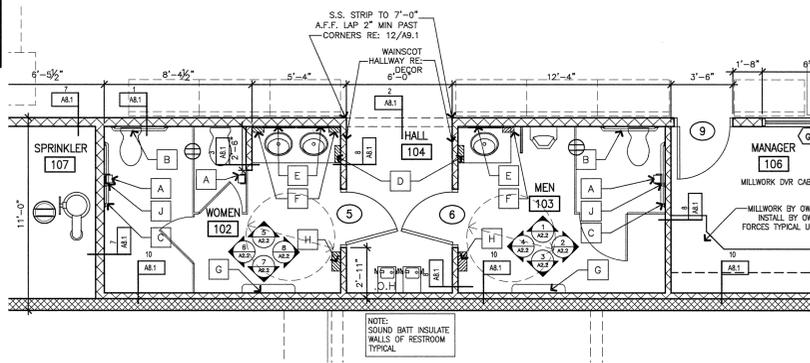

4 Enlarged Floor Plan  
SCALE: 1/4" = 1'-0"

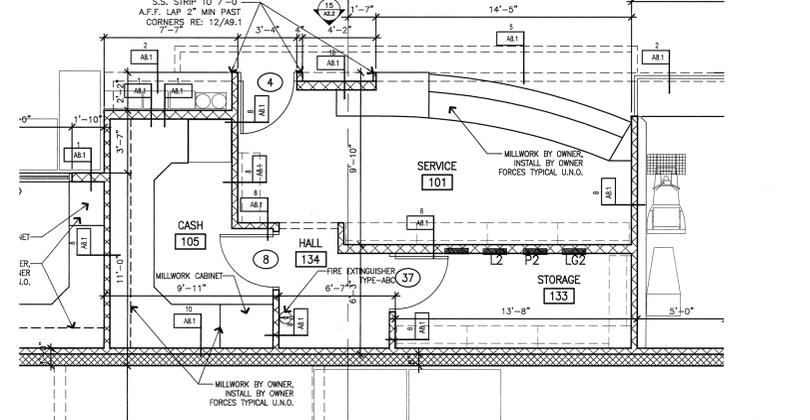

3 Enlarged Floor Plan  
SCALE: 1/4" = 1'-0"

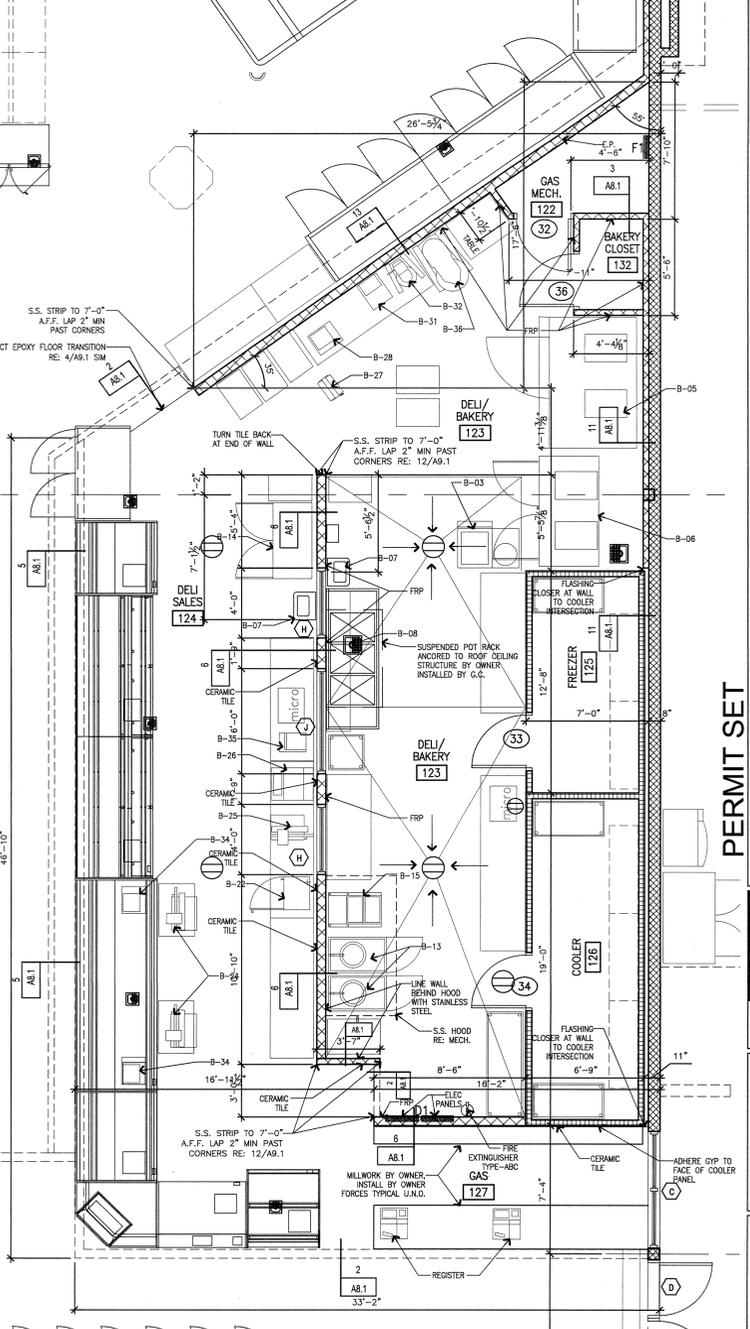

2 Enlarged Floor Plan  
SCALE: 1/4" = 1'-0"



NOTE: ALL SUBCONTRACTORS SHALL BE RESPONSIBLE FOR REVIEWING ALL DRAWINGS IN THE SET PRIOR TO PLACING BID.

PERMIT SET  
A New Grocery Facility for:  
**Harp's Food Stores (Store # )**  
Corner of E. Highland Drive and Harrisburg Rd.  
Jonesboro, Arkansas  
© J. Price Architecture, Inc. 2011 All Rights Reserved




REVISIONS:


ENLARGED FLOOR PLANS AND SCHEDULES  
PROJECT: 105 W Kansas Suite C Liberty, Missouri 64068 (816) 792-9991  
DATE: FEBRUARY 07, 2010  
SHEET NUMBER: A2.1




NOTE: ALL SUBCONTRACTORS SHALL BE RESPONSIBLE FOR REVIEWING ALL DRAWINGS IN THE SET PRIOR TO PLACING BID.

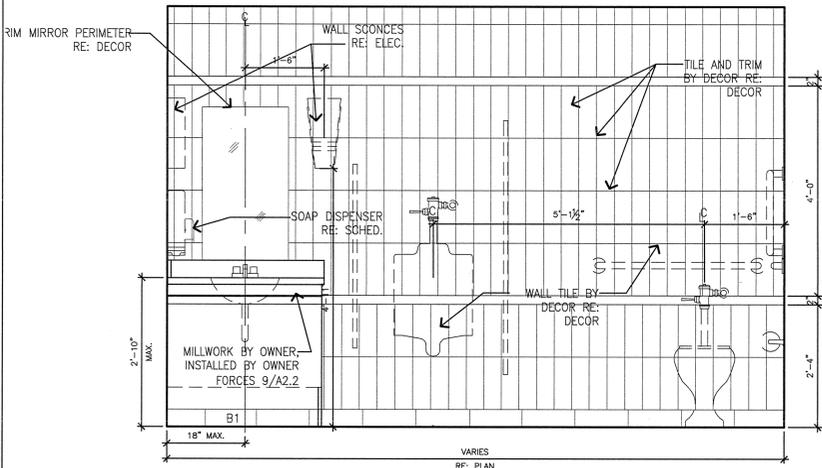


1 Men's Restroom Elevation  
SCALE: 3/4" = 1'-0"

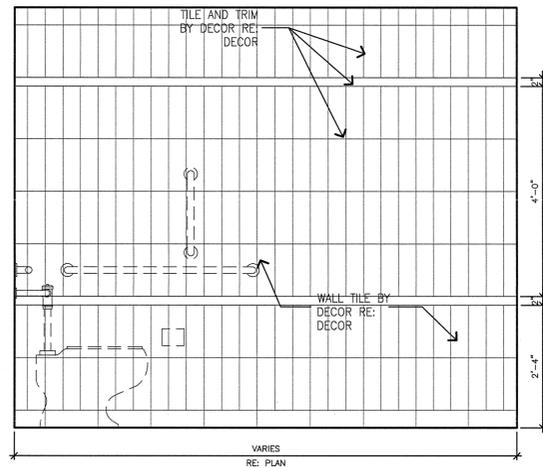


2 Men's Restroom Elevation  
SCALE: 3/4" = 1'-0"

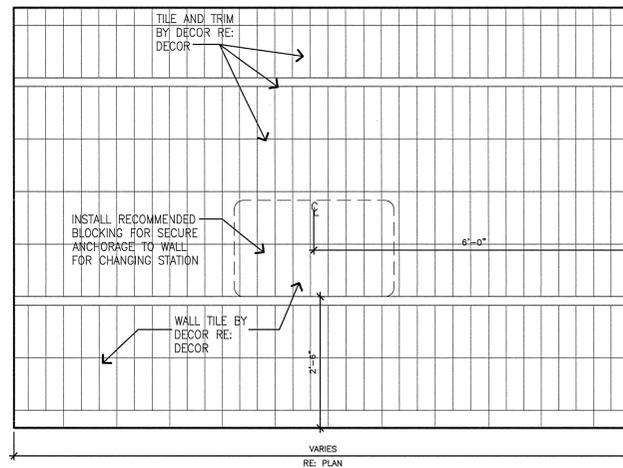


3 Men's Restroom Elevation  
SCALE: 3/4" = 1'-0"

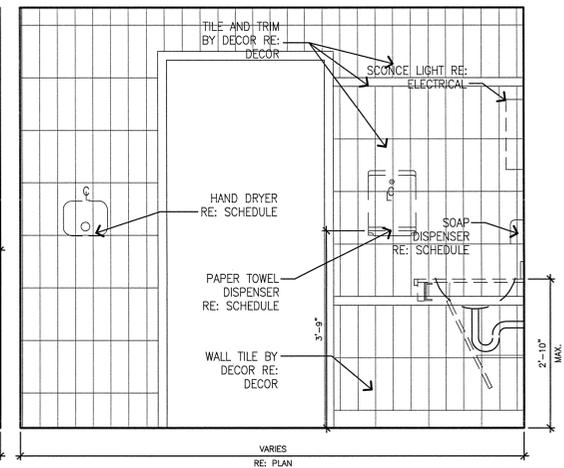


4 Men's Restroom Elevation  
SCALE: 3/4" = 1'-0"

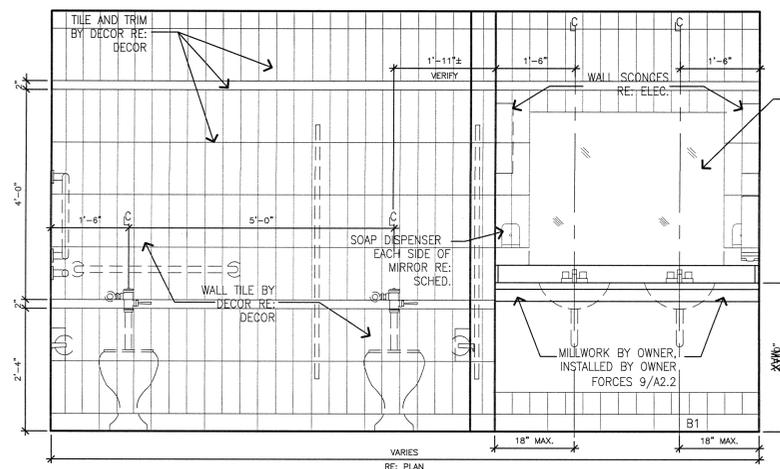


5 Women's Restroom Elevation  
SCALE: 3/4" = 1'-0"

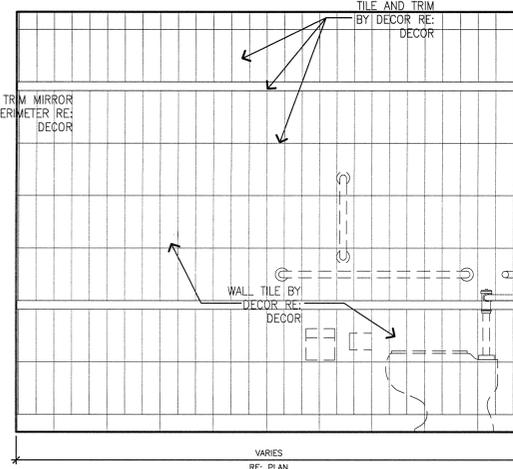


6 Women's Restroom Elevation  
SCALE: 3/4" = 1'-0"

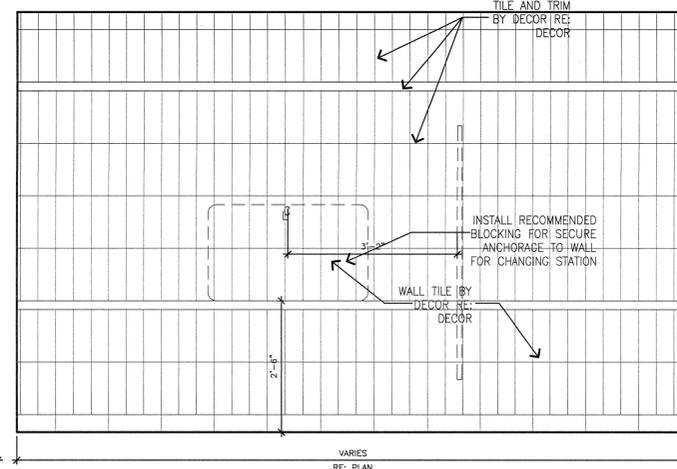


7 Women's Restroom Elevation  
SCALE: 3/4" = 1'-0"

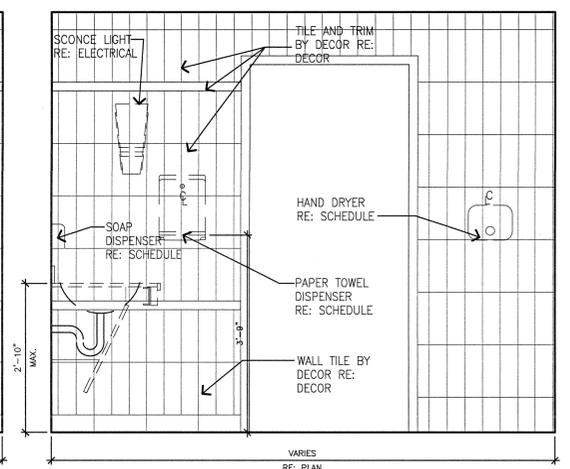


8 Women's Restroom Elevation  
SCALE: 3/4" = 1'-0"

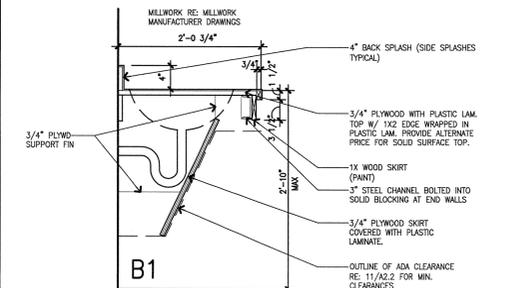

 
9 R.R. Millwork Vanity Section Detail  
SCALE: 1/2" = 1'-0"




10 Mirror Trim Detail  
SCALE: 6" = 1'-0"

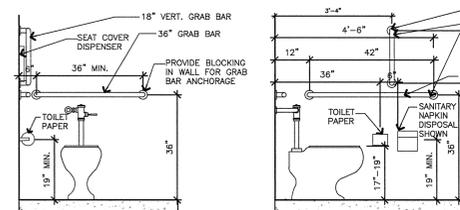


11 ADA Restroom Details  
SCALE: 1/2" = 1'-0"

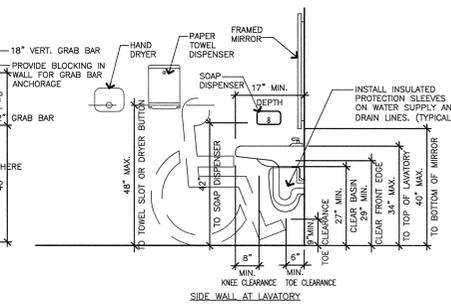


12 ADA Drinking Fountain Details  
SCALE: 3/4" = 1'-0"

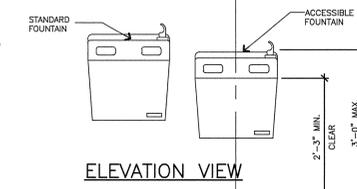


ELEVATION VIEW

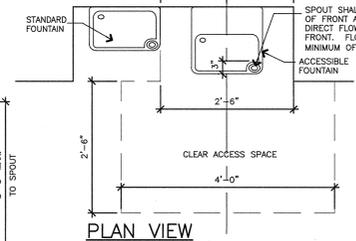


PLAN VIEW

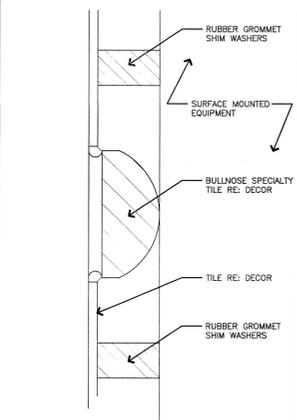

13 Typ. Shim Detail at Bullnose Tile  
SCALE: 6" = 1'-0"

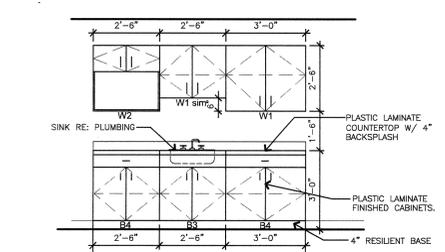

14 Break Room Elevation  
SCALE: 3/8" = 1'-0"

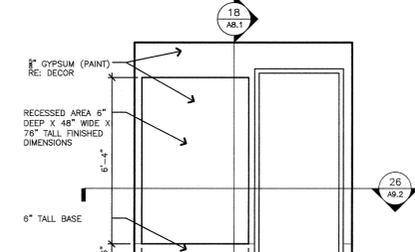

15 Interior Elevation @ Service  
SCALE: 3/8" = 1'-0"

PERMIT SET

A New Grocery Facility for:  
**Harp's Food Stores (Store # \_\_\_\_\_)**  
Corner of E. Highland Drive and Harrisburg Rd.  
Jonesboro, Arkansas  
© J. Price Architecture, Inc. 2011 All Rights Reserved



100 W Kansas  
Suite C  
Liberty, Missouri 64088  
(816) 792-8991

REVISIONS:

INTERIOR ELEVATIONS,  
DETAILS & ADA DETAILS  
PROJECT: FEBRUARY 09, 2010  
DATE: 10-04-11  
SHEET NUMBER:  
**A2.2**



NOTE: ARCHITECTS SHALL BE RESPONSIBLE FOR REVIEWING ALL DRAWINGS IN THE SET PRIOR TO PLACING BID.

PERMIT SET


A New Grocery Facility for:  
**Harp's Food Stores (Store # \_\_\_\_\_)**  
 Corner of E. Highland Drive and Harrisburg Rd.  
 Jonesboro, Arkansas  
 © J. Price Architecture, Inc. 2011. All Rights Reserved




105 W Kansas  
 Suite C  
 Liberty, Missouri 64068  
 (816) 792-9991

REVISIONS:


MILLWORK ELEVATIONS AND DETAILS  
 PROJECT: 10-04-01  
 DATE: FEBRUARY 02, 2010  
 SHEET NUMBER: **A2.3**

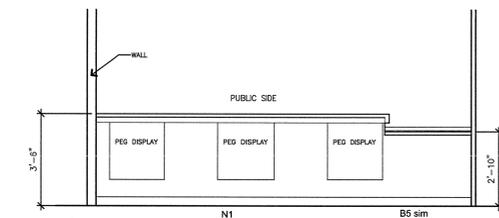


**10 Interior Elevation @ Customer Service**  
 SCALE: 3/8" = 1'-0"

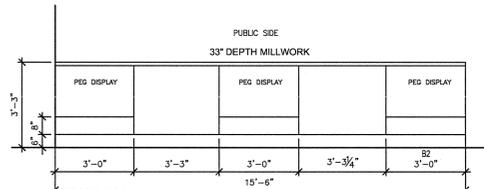


**7 Interior Elevation @ Gas Counter**  
 SCALE: 3/8" = 1'-0"

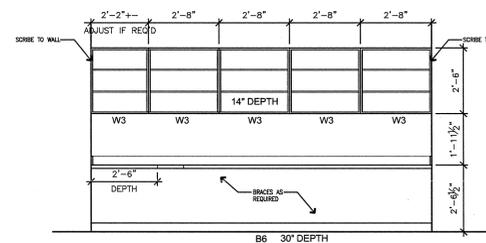


**4 Interior Elevation @ Scan Office**  
 SCALE: 3/8" = 1'-0"

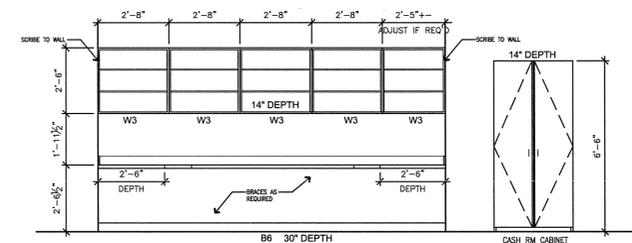


**1 Interior Elevation @ Cash Office**  
 SCALE: 3/8" = 1'-0"

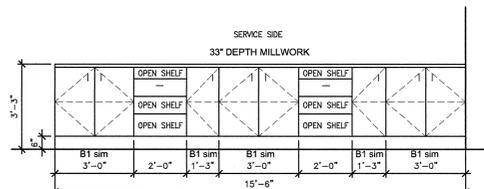


**8 Interior Elevation @ Gas Counter**  
 SCALE: 3/8" = 1'-0"

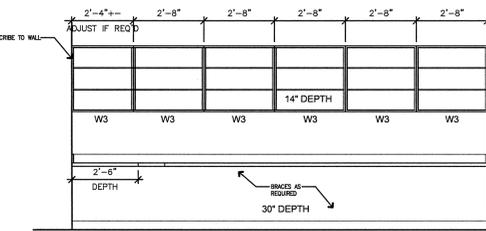


**5 Interior Elevation @ Dept. Manager**  
 SCALE: 3/8" = 1'-0"

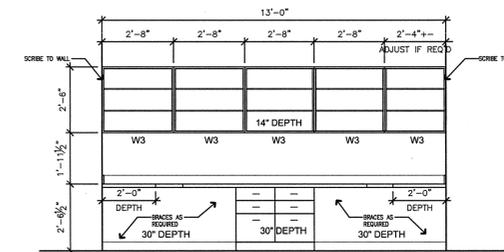


**2 Elevation @ Manager Office 106**  
 SCALE: 3/8" = 1'-0"

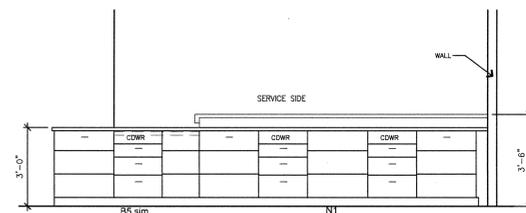

**9 Interior Elevation @ Customer Service**  
 SCALE: 3/8" = 1'-0"

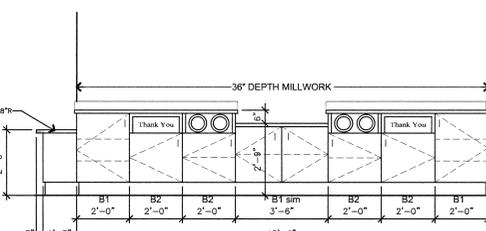


**6 Interior Elevation @ Drink Counter**  
 SCALE: 3/8" = 1'-0"

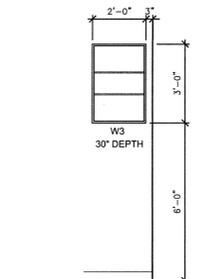


**3 Elevation @ Manager DVR Cabinet**  
 SCALE: 3/8" = 1'-0"


MILLWORK DETAILS:

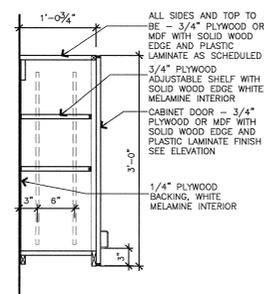


W1

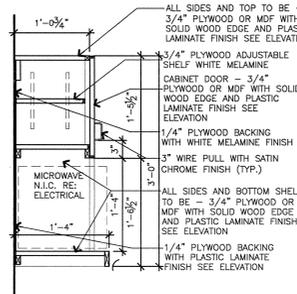


W2

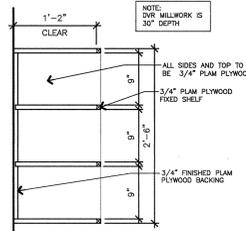


W3

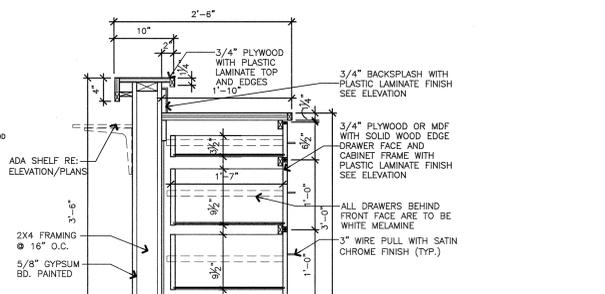


N1

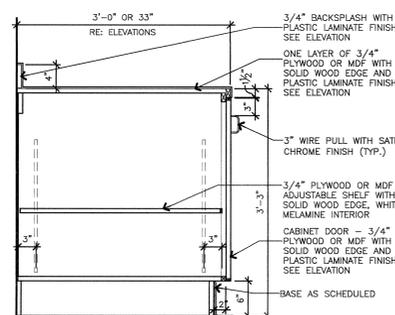


B1

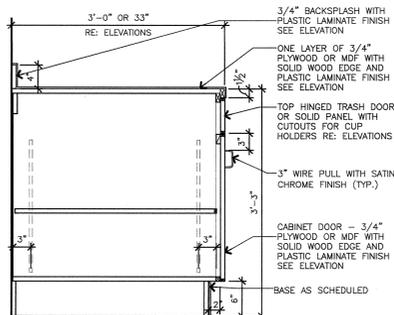


B2

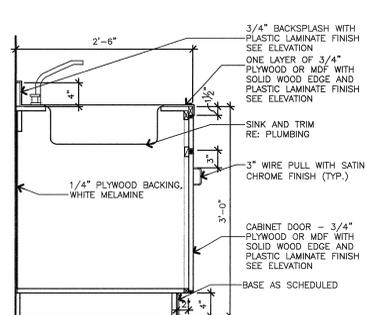


B3

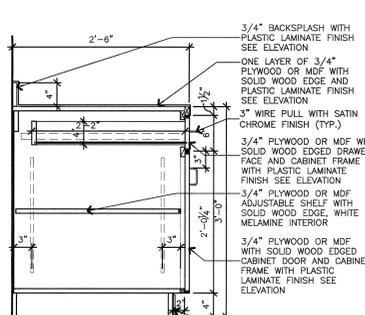


B4

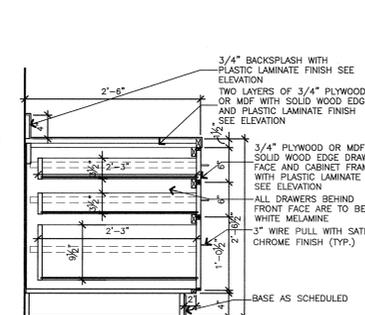







B5

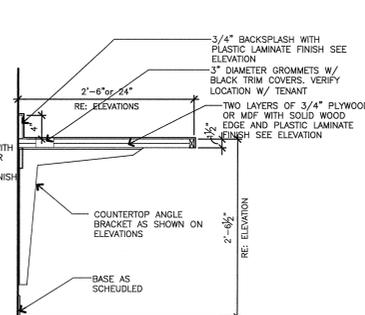

B6

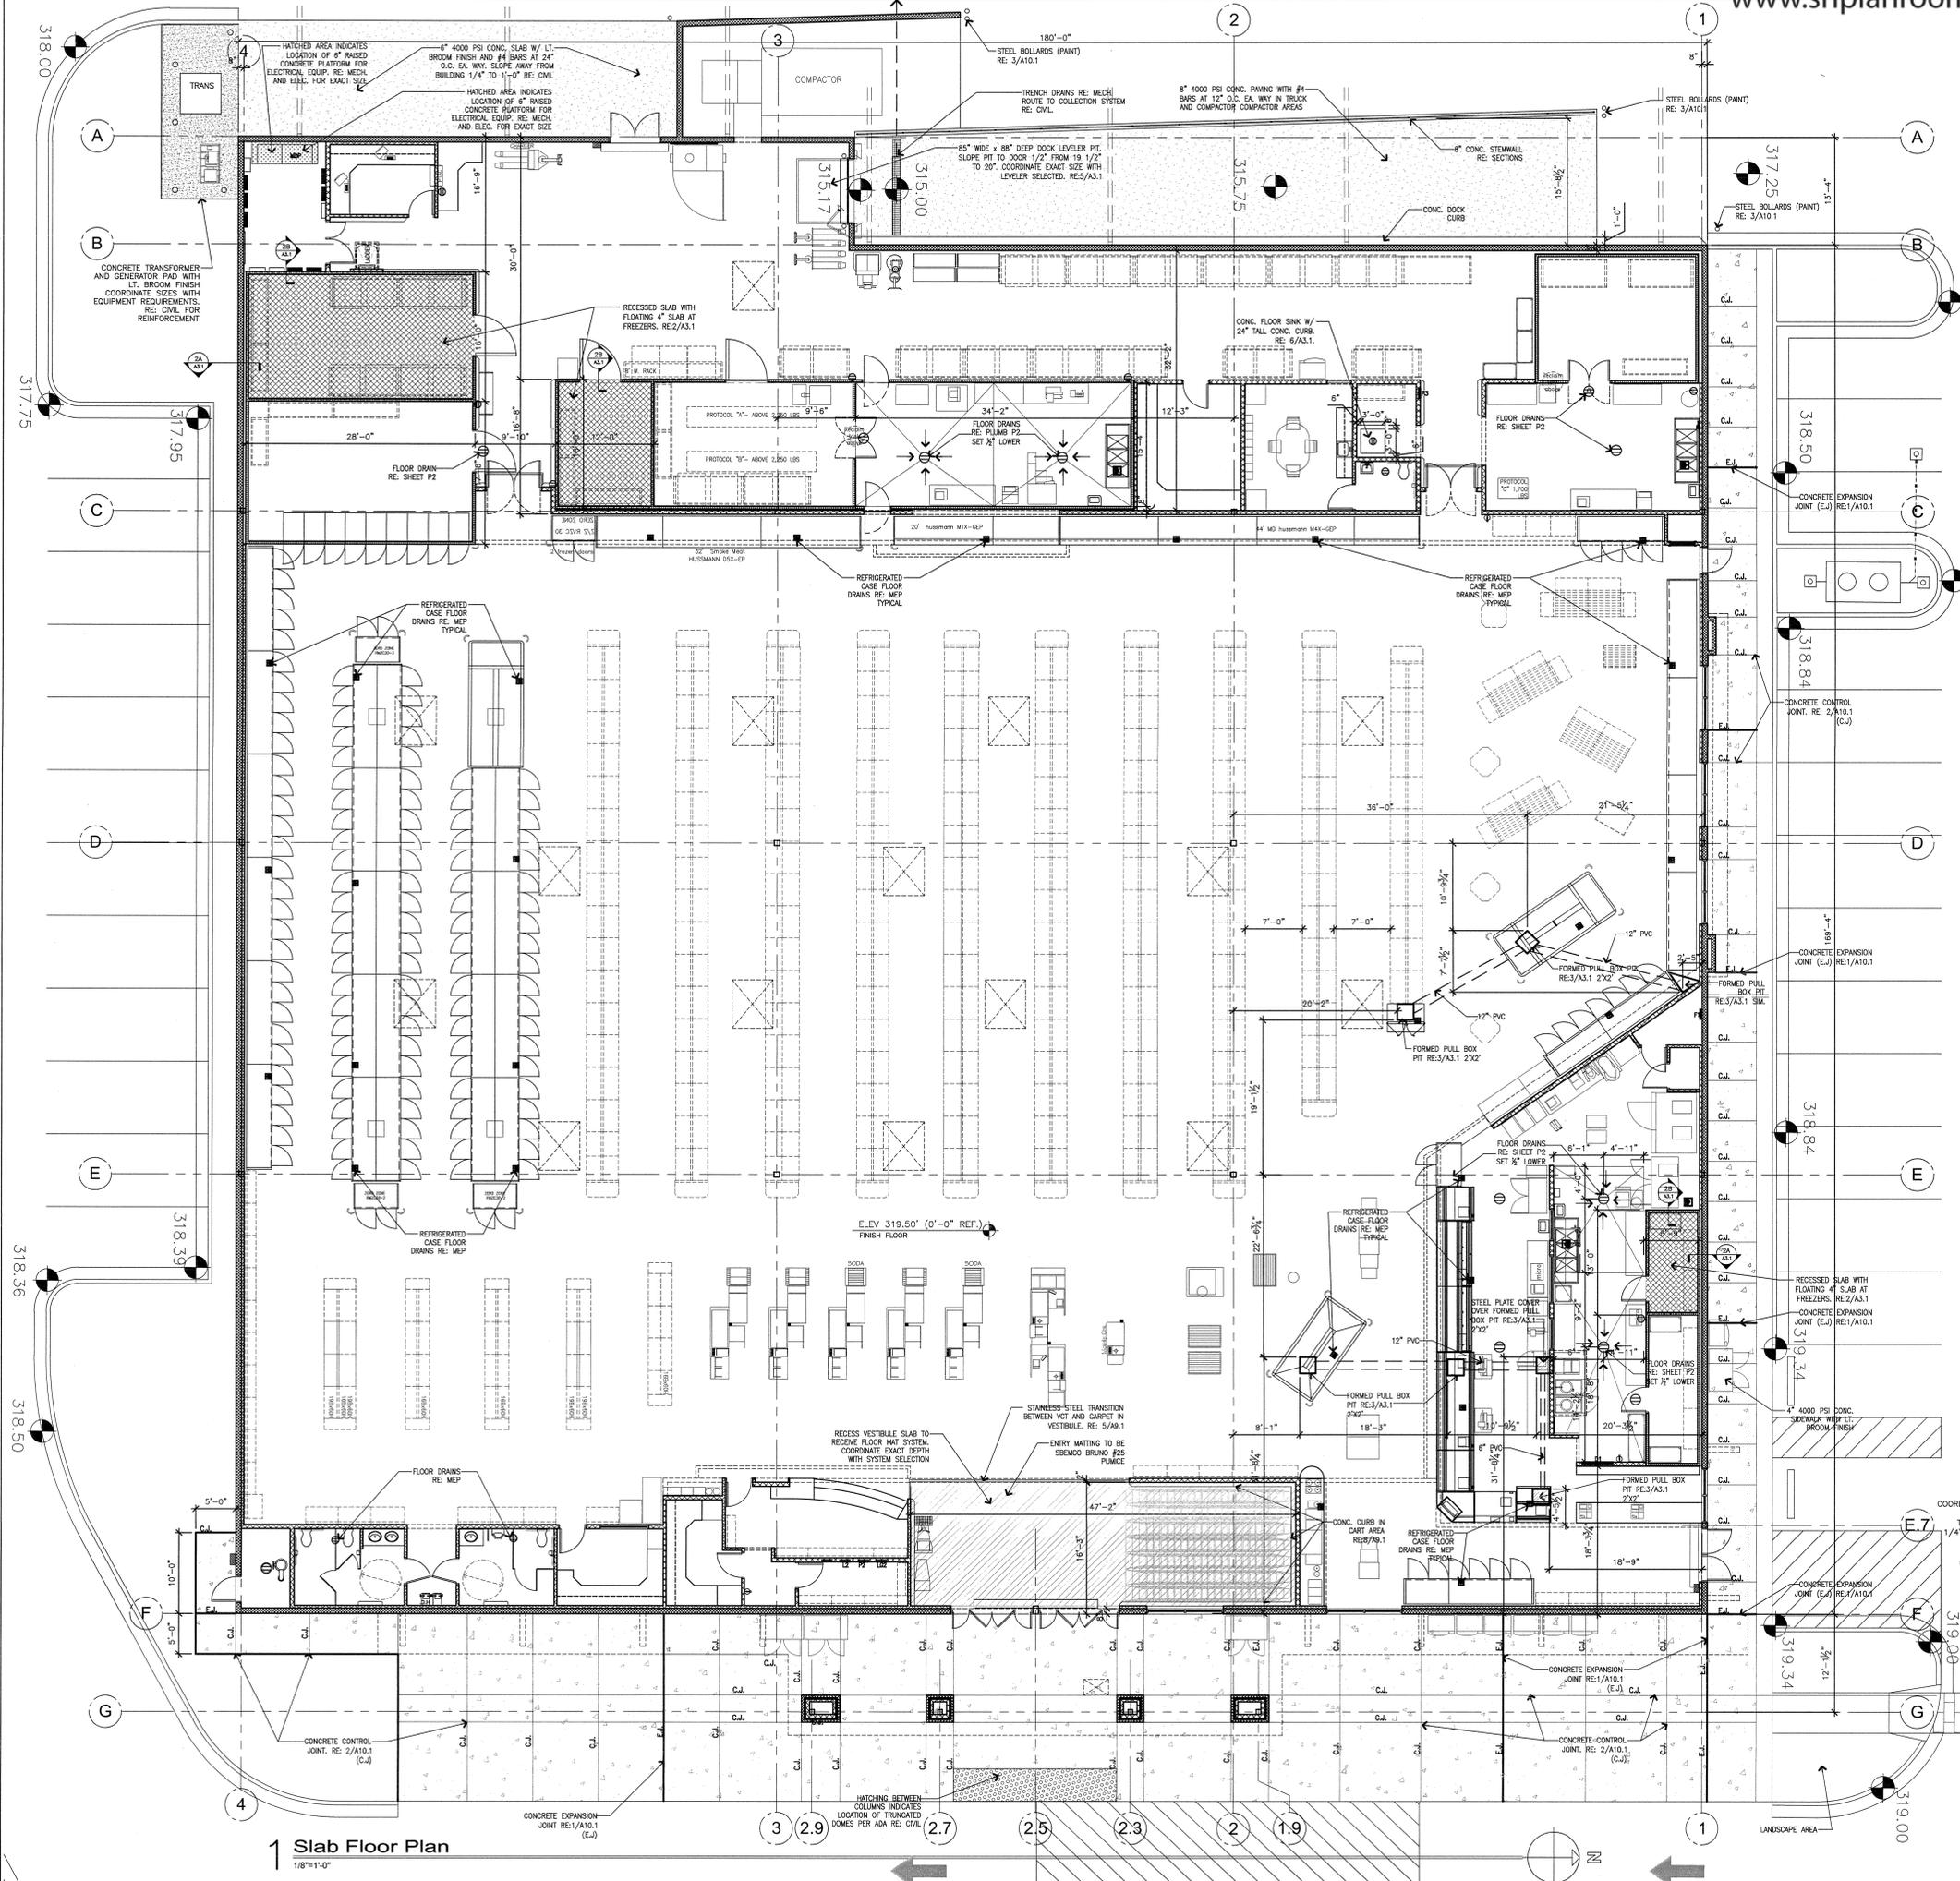


1 Slab Floor Plan  
1/8"=1'-0"

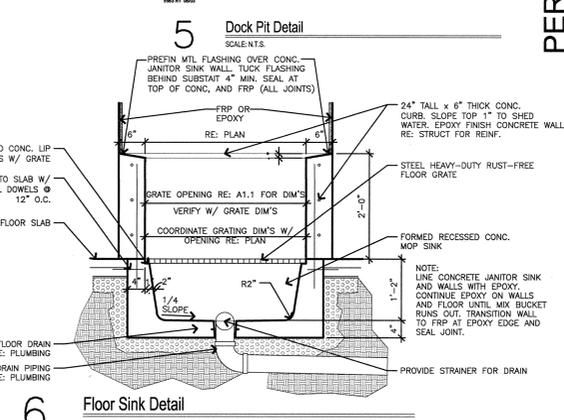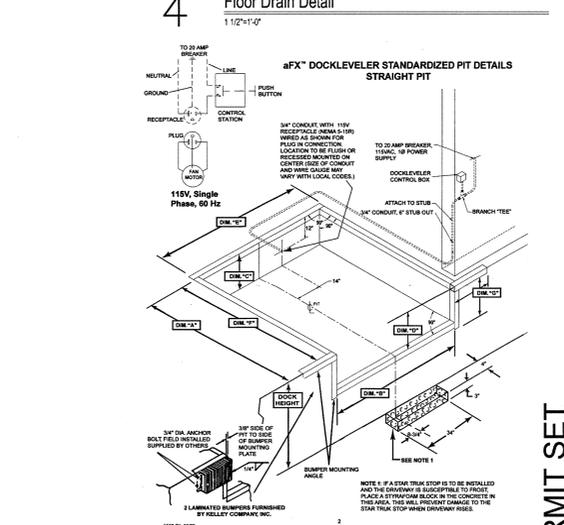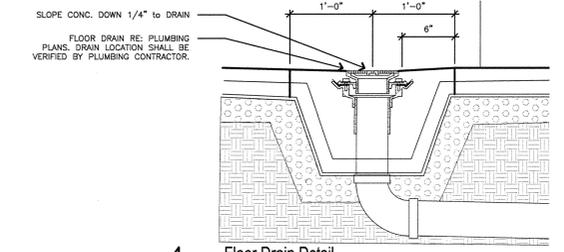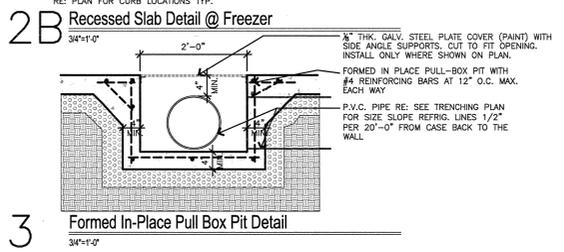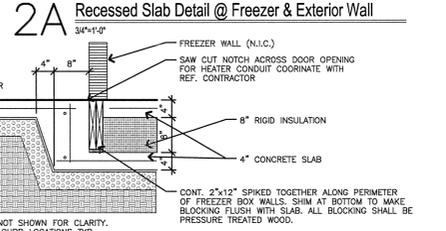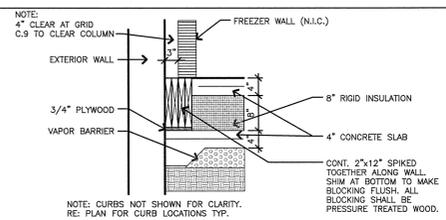

**FLOOR SLAB NOTES:**

1. THIS PLAN IS INTENDED TO INDICATE LOCATIONS OF RECESSED FLOOR SLABS, FLOOR SINKS, DOCK PITS AND TRENCH DRAINS. NOT ALL DRAINS ARE INDICATED ON THIS PLAN. CONTRACTOR SHALL VERIFY THAT PLUMBING SUBCONTRACTOR HAS REVIEWED THIS PLAN AND HAS ACCOUNTED FOR ALL TRENCH DRAINS INDICATED ON THIS PLAN AS WELL AS THE PLUMBING PLAN. DRAINS SHOWN ON EITHER PLAN ARE PART OF THE CONTRACT AND THE RESPONSIBILITY OF THE PLUMBING CONTRACTOR.
2. REFER TO ENLARGED PLANS FOR MORE DETAILED DIMENSIONS IN FOOD PREP AREAS.
3. NOTIFY ARCHITECT OF DISCREPANCIES BETWEEN ENGINEERING AND ARCHITECTURAL DRAWINGS. IF ANY ITEM APPEARS ON EITHER SHEET, THE ASSUMPTION MUST BE MADE THAT IT IS REQUIRED.
4. COORDINATE INSTALLATION OF REFRIGERATION PIPING W/ OWNERS REFRIGERATION CONTRACTOR BEFORE CONCRETE POUR.

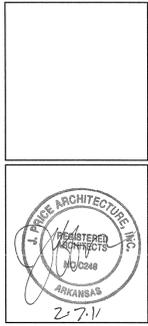


DATE: 10-24-11  
SHEET NUMBER: A3.1

PERMIT SET  
A New Grocery Facility for:  
**Harp's Food Stores** (Store # \_\_\_\_\_)  
Corner of E. Highland Drive and Harrisburg Rd.  
Jonesboro, Arkansas  
© J. Price Architecture, Inc. 2011 All Rights Reserved



105 W Harris  
Suite C  
Liberty, Missouri 64068  
(816) 792-8991  
REVISIONS:  
DATE: 10-24-11  
SHEET NUMBER: A3.1

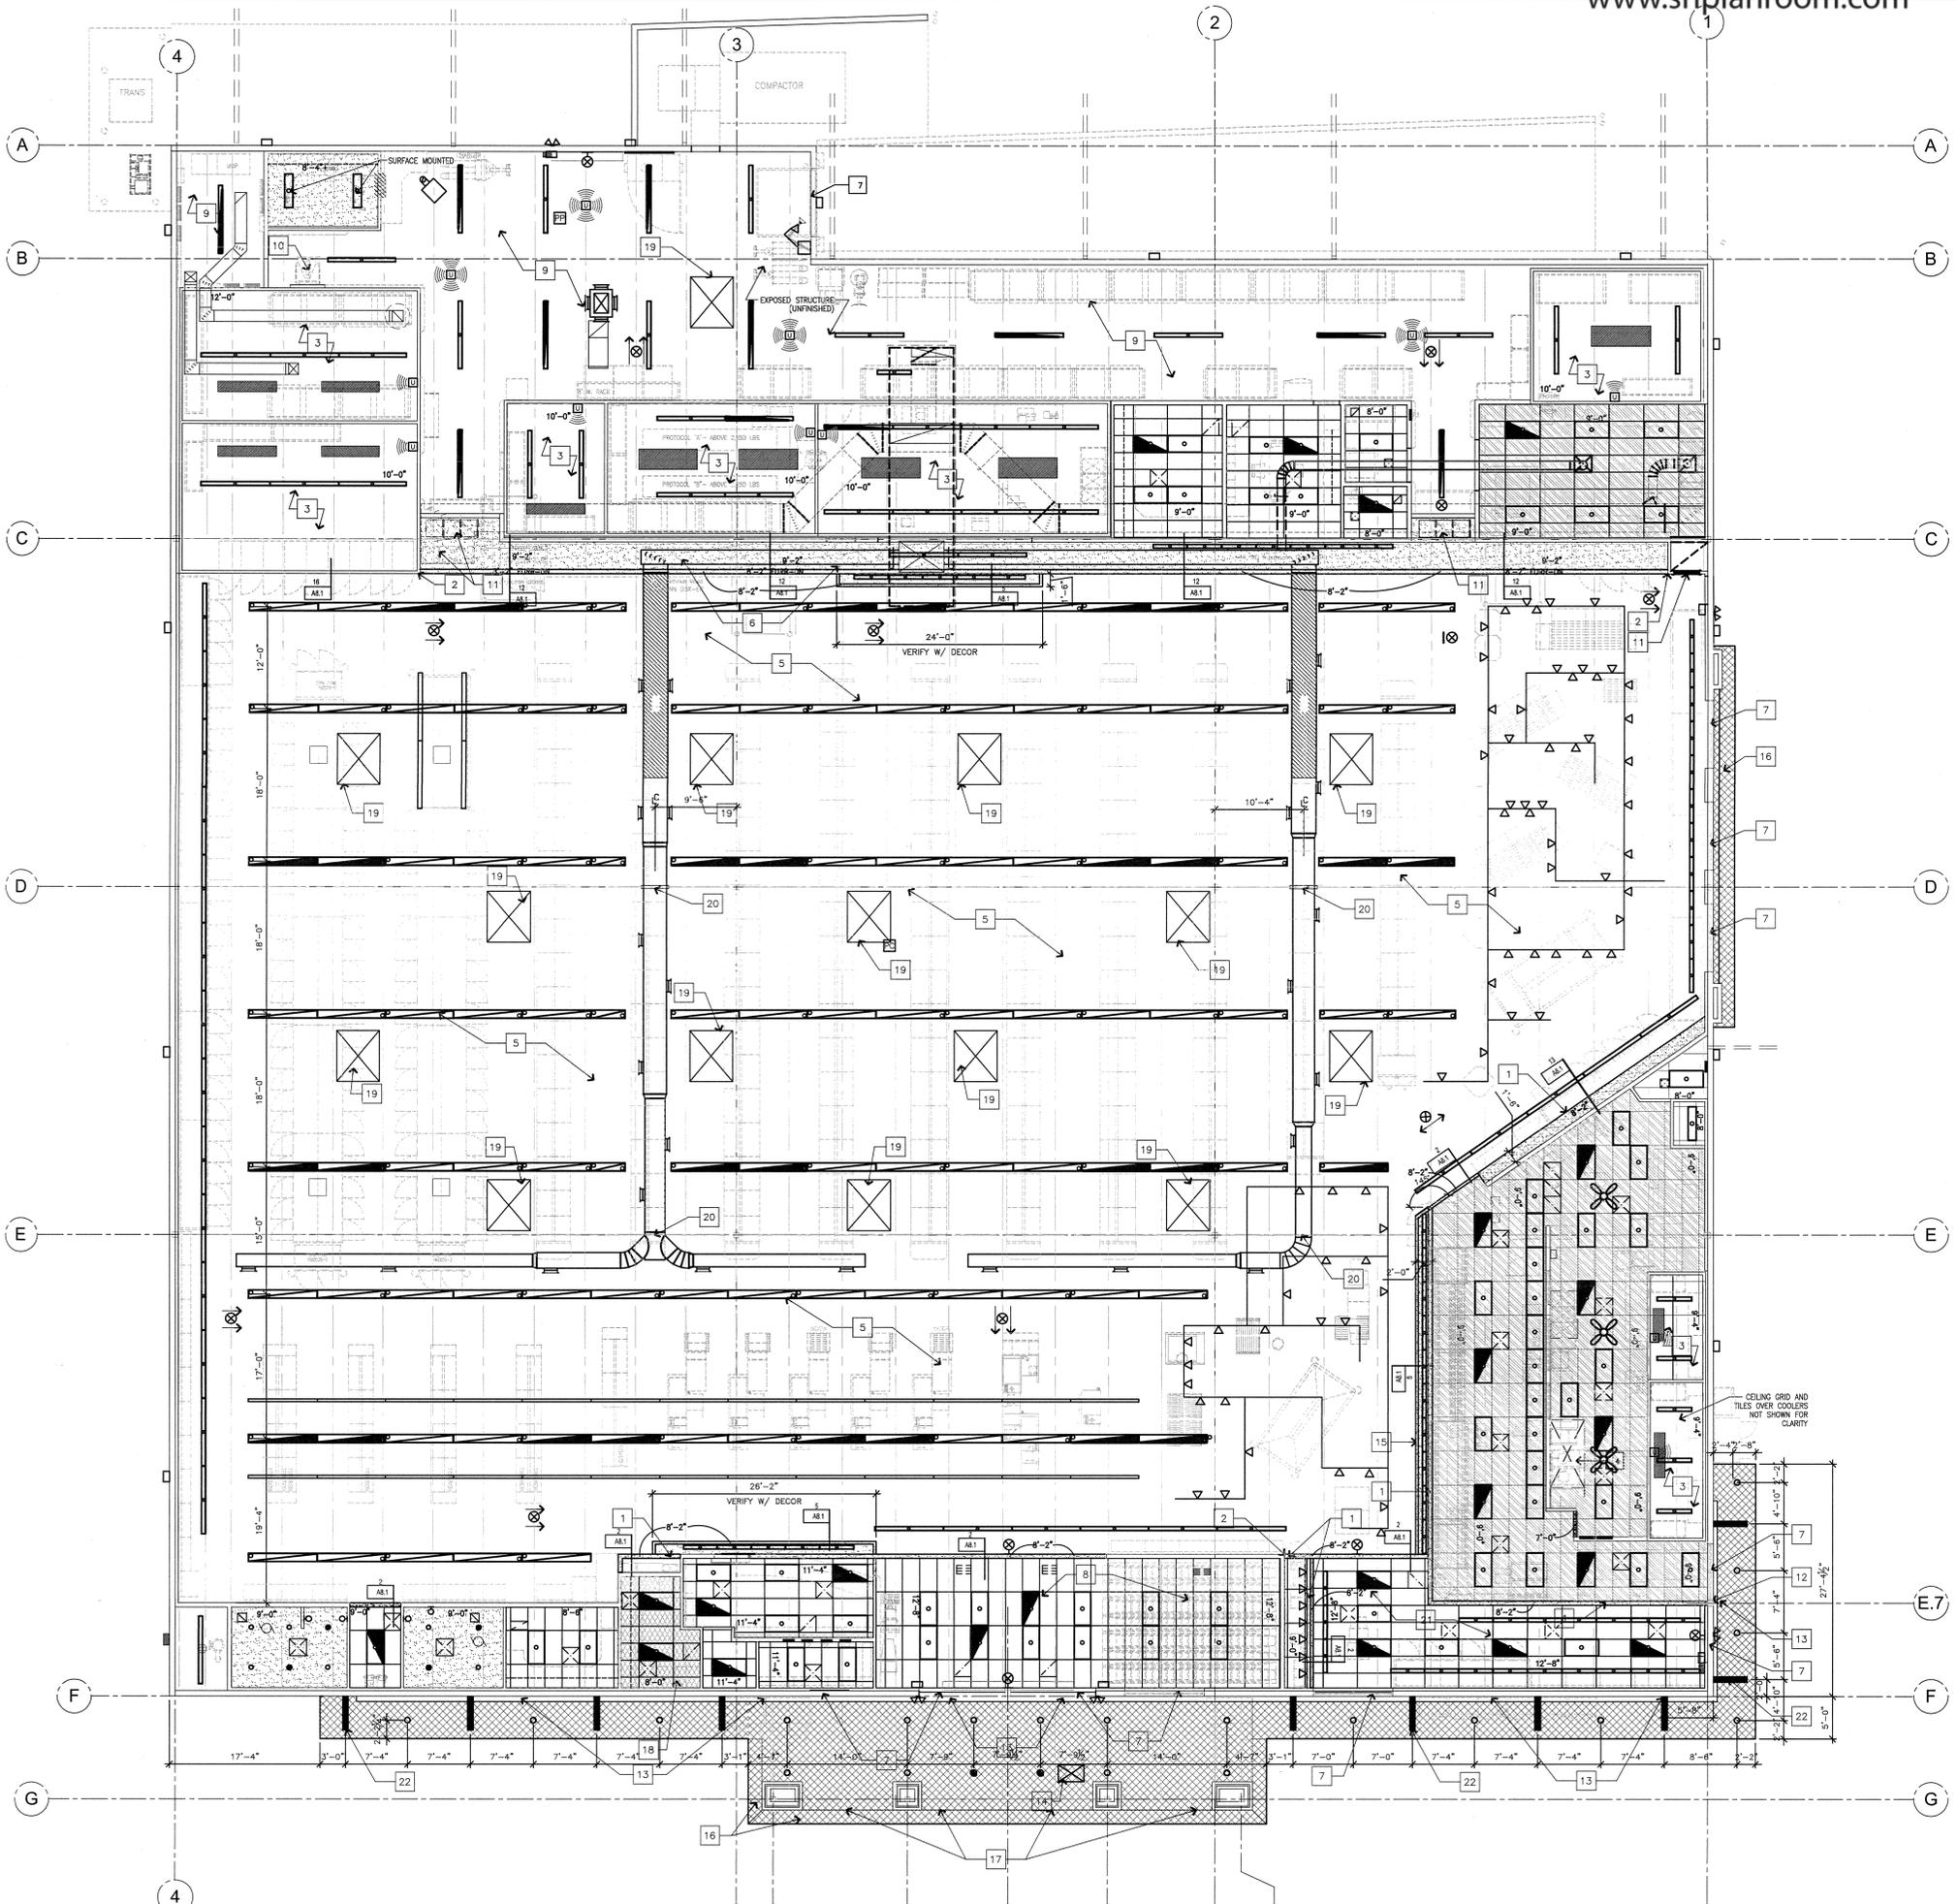

1 Reflected Ceiling Plan  
1/8"=1'-0"

REFLECTED CEILING LEGEND	
SYMBOL	DESCRIPTION
[Symbol]	2X4 LAY-IN CEILING EQUAL TO USG RADAR 2310 OR ARMSTRONG CORTEGA 769 IN 15/16" WHITE GRID.
[Symbol]	2X2 LAY-IN CEILING EQUAL TO USG RADAR 2120 IN 15/16" GRID. (SELECT TILE AND GRID FROM STANDARD COLORS)
[Symbol]	LIGHT FIXTURES: RE: ELEC. FOR TYPE
[Symbol]	2X2 SUPPLY GRILLE RE: MECH
[Symbol]	2X2 RETURN GRILLE RE: MECH
[Symbol]	EMERGENCY EXIT SIGN RE: ELEC.
[Symbol]	NOTE INDICATES CEILING HEIGHT A.F.F. COORDINATE WITH MECH. AND EXISTING CONDITIONS.
[Symbol]	EXTERIOR WALL-PACK RE: ELECTRICAL
[Symbol]	RECESSED CANISTER LIGHT FIXTURE
[Symbol]	ADJUSTABLE CANISTER LIGHT FIXTURE
[Symbol]	TRACK LIGHTING
[Symbol]	CLEANABLE LAY-IN CEILING PANELS (GYPSUM OR VINYL FACED-IN ALUMINUM GRID SYSTEM)
[Symbol]	GYPSUM CEILING (PAINT)
[Symbol]	3/4" E.L.F.S. SOFFIT

- REFLECTED CEILING GENERAL NOTES:**
1. PROVIDE CEILING HOLD DOWN CLIPS IN ALL VESTIBULE CEILINGS AND CEILINGS WHERE UPLIFT ON TILES IS POSSIBLE. (TYPICAL)
  2. ALL CEILINGS NOTED TO BE CLEANABLE, PROVIDE ALUMINUM GRID AND MATCH PROFILE OF GRID SPECIFIED. (TYPICAL)
  3. PAINT ALL EXPOSED DUCTWORK, PIPING, CONDUIT, ETC. IN SALES FLOOR

- REFLECTED CEILING PLAN KEYNOTES:**
- 1 GYPSUM FURREDOWN REA8.1 FOR CONDITIONS
  - 2 ALIGN EDGE OF GYPSUM FURR-DOWN WITH WALL CORNER.
  - 3 PREFABRICATED COOLER CEILING. RE: COOLER DRAWINGS
  - 4 NEW HOOD. REMEDICAL
  - 5 EXPOSED STEEL STRUCTURE (PAINT)
  - 6 BOX PLENUM. COORDINATE WITH MECHANICAL
  - 7 STEEL BEAM OR LINTEOLAE (PAINT)
  - 8 INSTALL HOLD DOWN CLIPS IN VESTIBULE CEILING
  - 9 EXPOSED ROOF STRUCTURE (NO FINISH)
  - 10 ROOF ACCESS HATCH
  - 11 RETURN AIR LOUVER. (PAINT) RE: MECHANICAL
  - 12 ALIGN CENTER OF GYP FURR DOWN W/ CENTER OF TUBE COLUMN
  - 13 CONTINUOUS 3" VENT IN E.L.F.S. SOFFIT. PAINT TO MATCH E.L.F.S.
  - 14 SOFFIT ACCESS PANEL (PAINT TO MATCH E.L.F.S.)
  - 15 GYPSUM LITE SHELF. RE: DECOR DRAWINGS
  - 16 PARAPET W/ E.L.F.S. FINISH
  - 17 STEEL CHANNEL ABOVE (PAINT)
  - 18 EXPANDED METAL SECURITY STRUCTURE ABOVE LAY-IN CEILING IN CASH ROOM.
  - 19 SKYLIGHTS WITH FALL GUARDS (PAINT GUARDS TO MATCH ROOF AND STRUCTURE). RE: AS.1 FOR EXACT LOCATIONS
  - 20 GRIDDER MANUFACTURER SHALL DESIGN GRIDDER TO ALLOW FOR DUCT PENETRATION IN AREAS SHOWN ON DUCT LAYOUT. DUCT SHOULD BE CENTERED BETWEEN JOISTS IN SIZES INDICATED. NOTIFY ARCHITECT OF CONDITIONS PRIOR TO GRIDDER FABRICATION. BLACK GRID ONLY-NO LAY-IN CEILING TILES THIS AREA. PAINT STRUCTURE ABOVE GRID BLACK.
  - 21 DECORATIVE WOOD BRACKETS. RE: 1/A6.1 & 8/A7.1
  - 22

**PERMIT SET**


A New Grocery Facility for:  
**Harp's Food Stores (Store # \_\_\_\_\_)**

Corner of E. Highland Drive and Harrisburg Rd.  
Jonesboro, Arkansas  
© J. Price Architecture, Inc. 2011. All Rights Reserved


105 W. Kansas  
Suite C  
Liberty, Missouri 64068  
(816) 792-9991  
J. PRICE ARCHITECTURE, INC.

REVISIONS:

PROJECT:	DATE:
10-0411	FEBRUARY 07, 2010
SHEET NUMBER:	<b>A4.1</b>

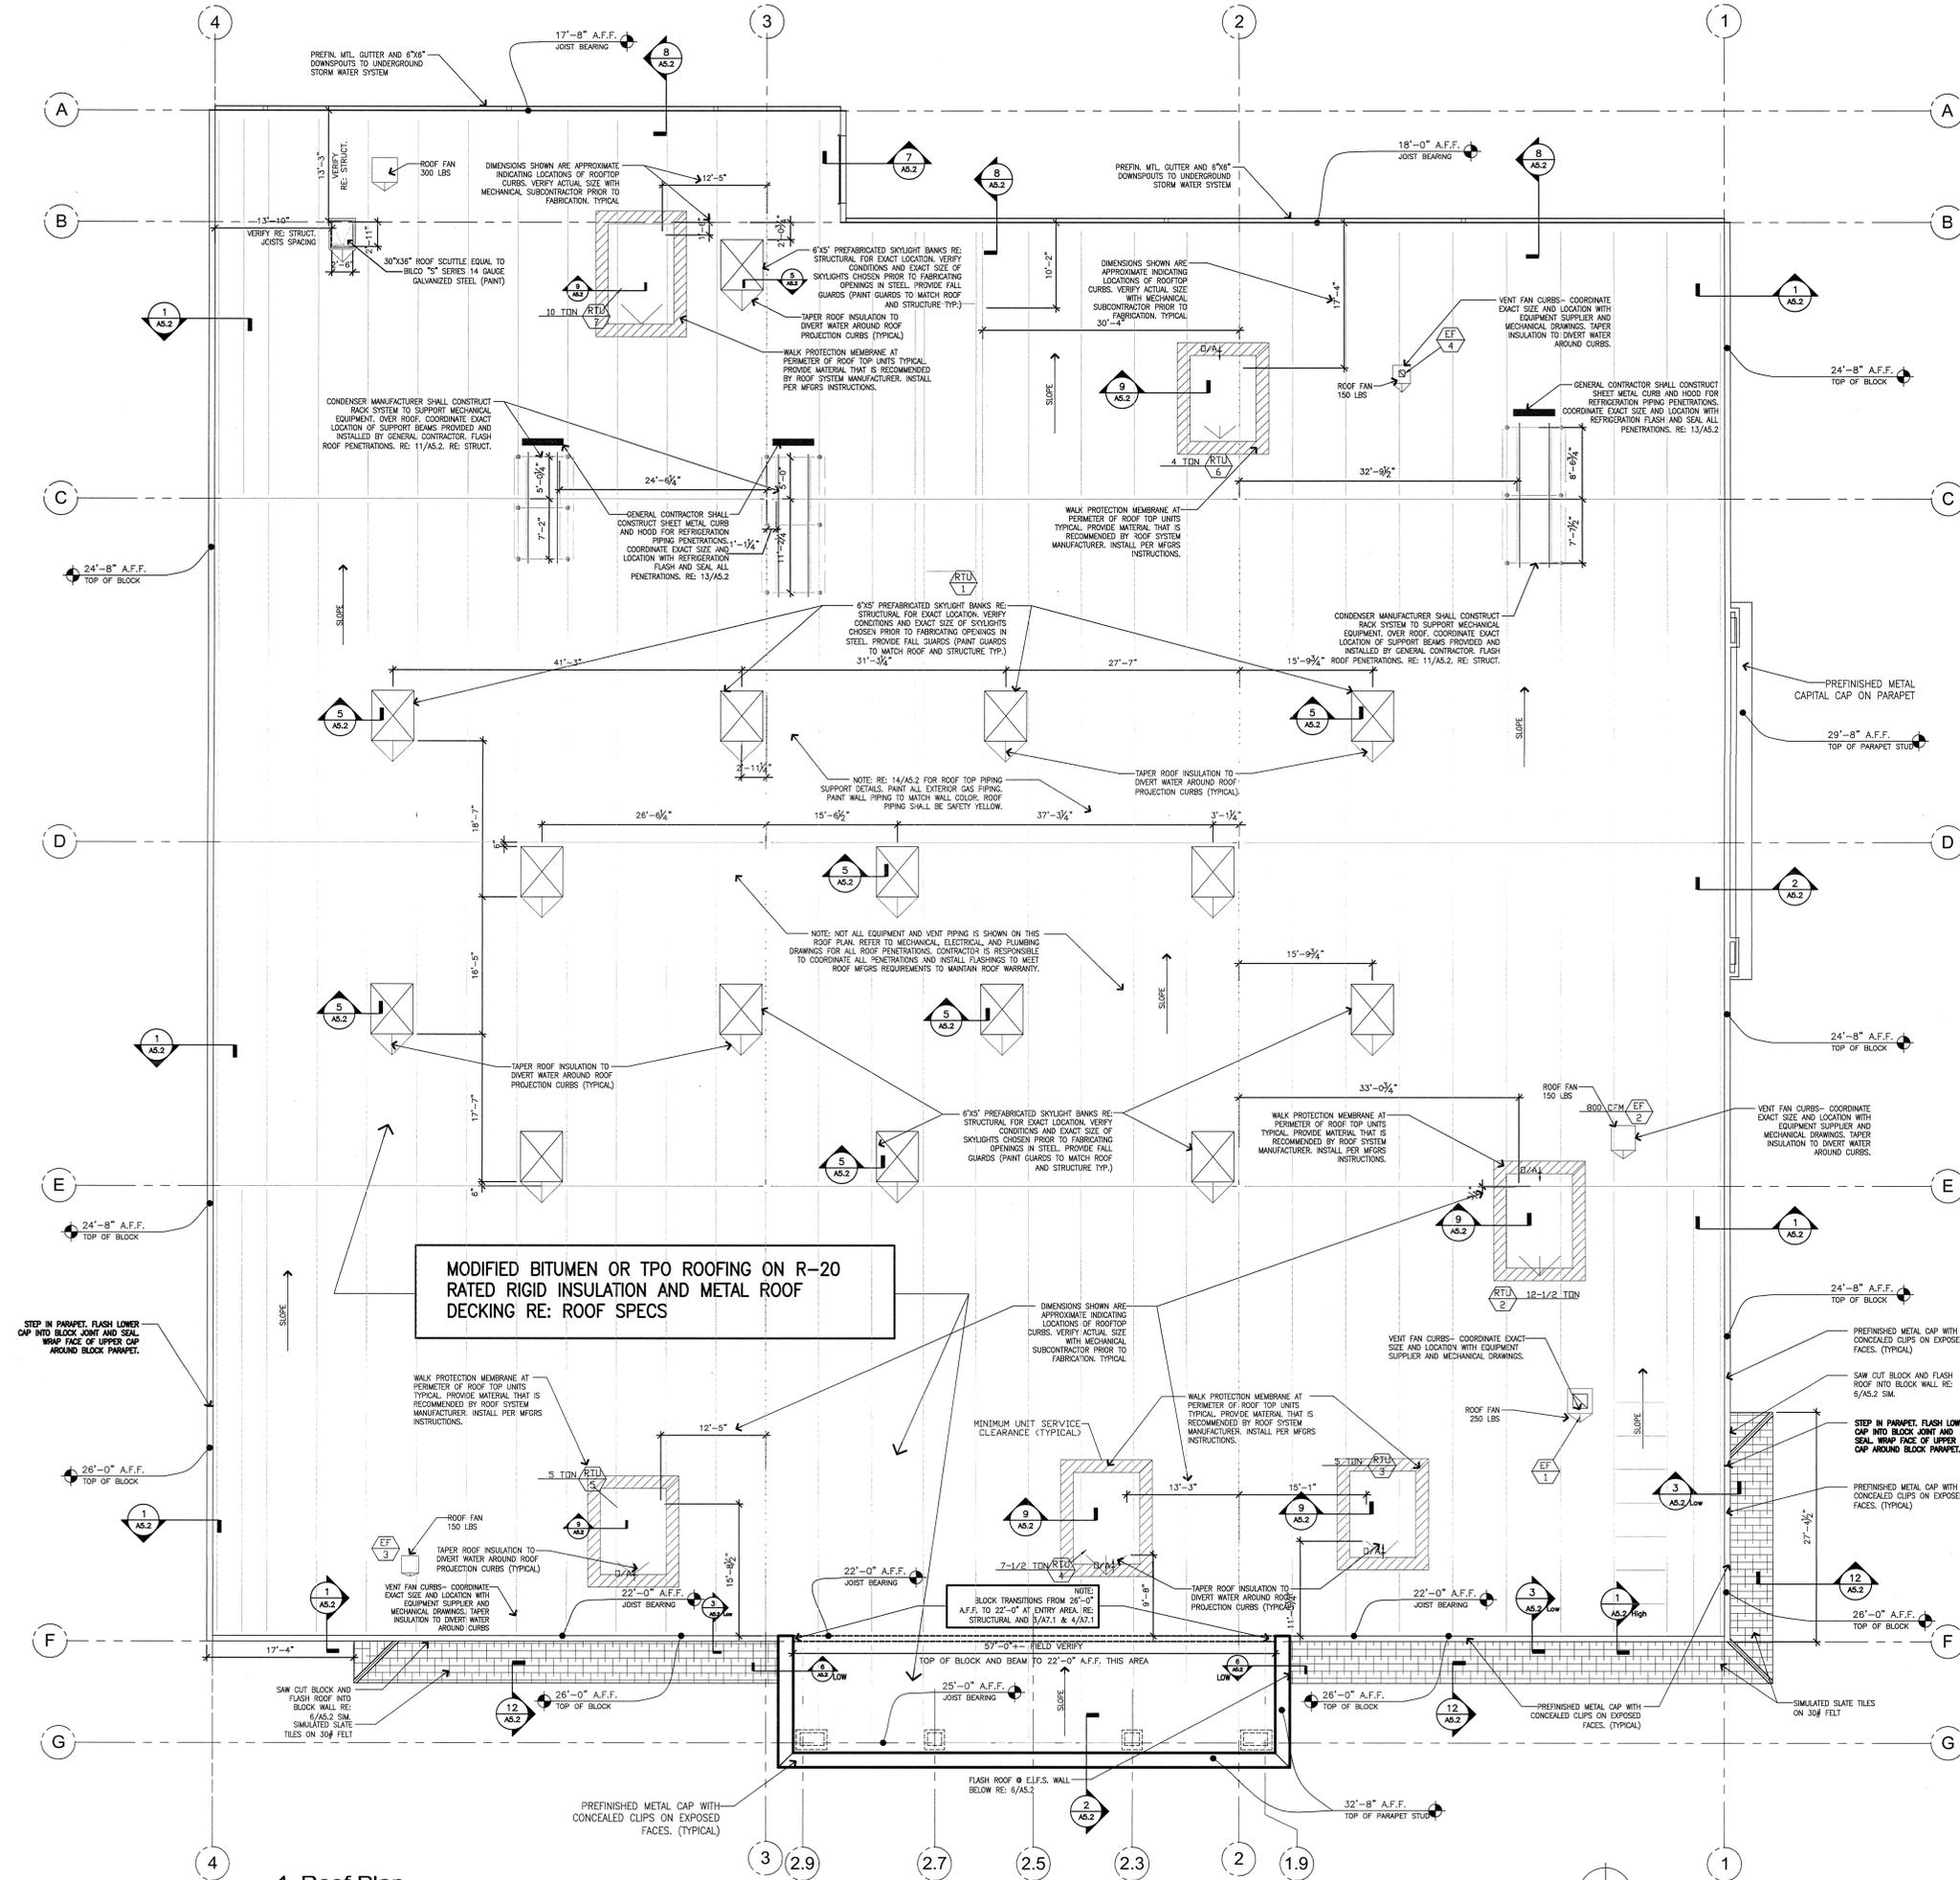

1 Roof Plan  
1/8"=1'-0"

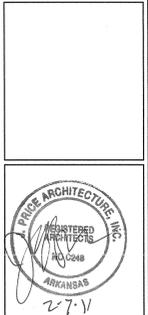

NOTE:  
ALL SUBCONTRACTORS SHALL BE RESPONSIBLE FOR REVIEWING ALL DRAWINGS IN THE SET PRIOR TO PLACING BID.


PERMIT SET  
A New Grocery Facility for:  
**Harp's Food Stores (Store # )**  
Corner of E. Highland Drive and Harrisburg Rd.  
Jonesboro, Arkansas  
© J. Price Architecture, Inc. 2011 All Rights Reserved



105 W Kansas  
Suite C  
Liberty, Missouri 64068  
(816) 792-5991


REVISIONS:

PROJECT: DATE: PERMITTED BY: SHEET NUMBER: **A5.1**

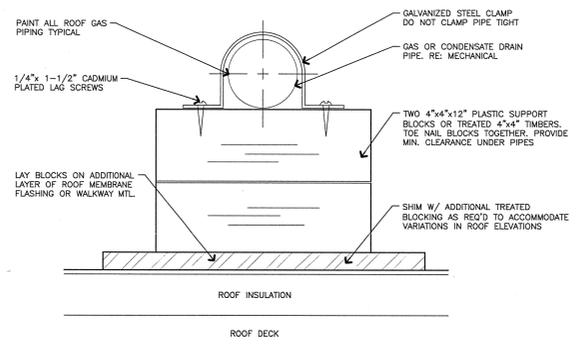


NOTE: LOCATE SUPPORTS AT 4' SPACING FOR PLASTIC PIPE AND AT THE FOLLOWING SPACING FOR METAL PIPE: 5\"/>


14 Roof Blocking Detail  
SCALE: 3\"/>

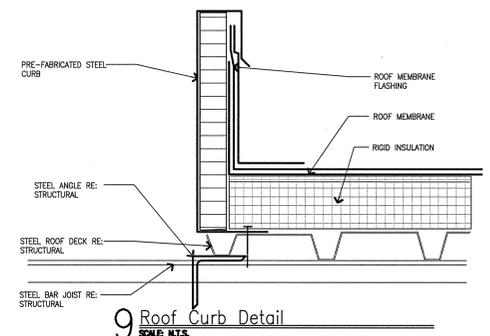


9 Roof Curb Detail  
SCALE: N.T.S.

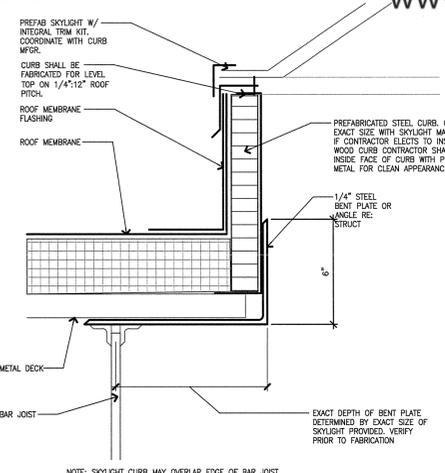


5 Skylight Curb Detail  
SCALE: 3\"/>

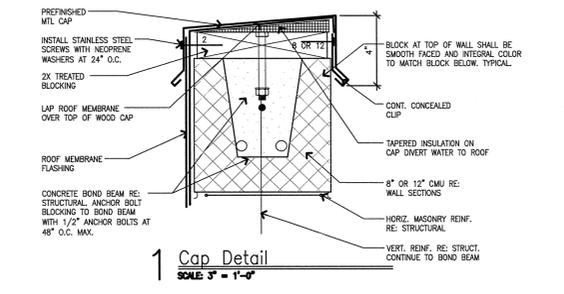


1 Cap Detail  
SCALE: 3\"/>

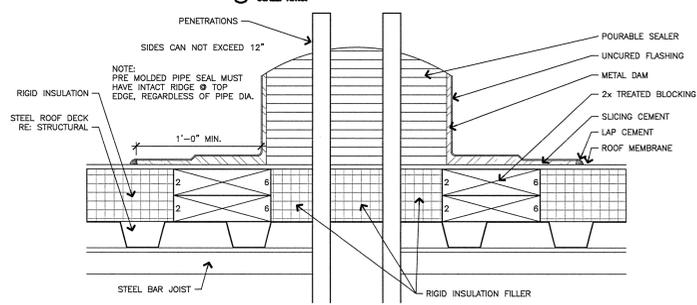


10 Roof Penetration Detail  
SCALE: N.T.S.

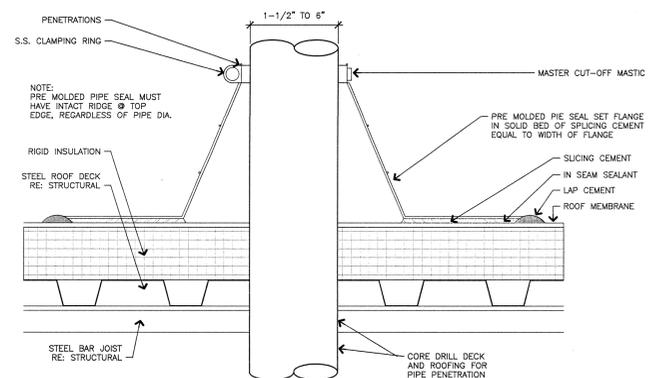


11 Roof Penetration Detail  
SCALE: N.T.S.

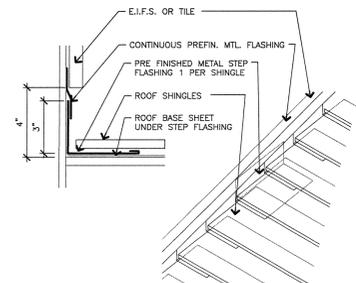


6 Step Flashing Detail  
SCALE: 3\"/>

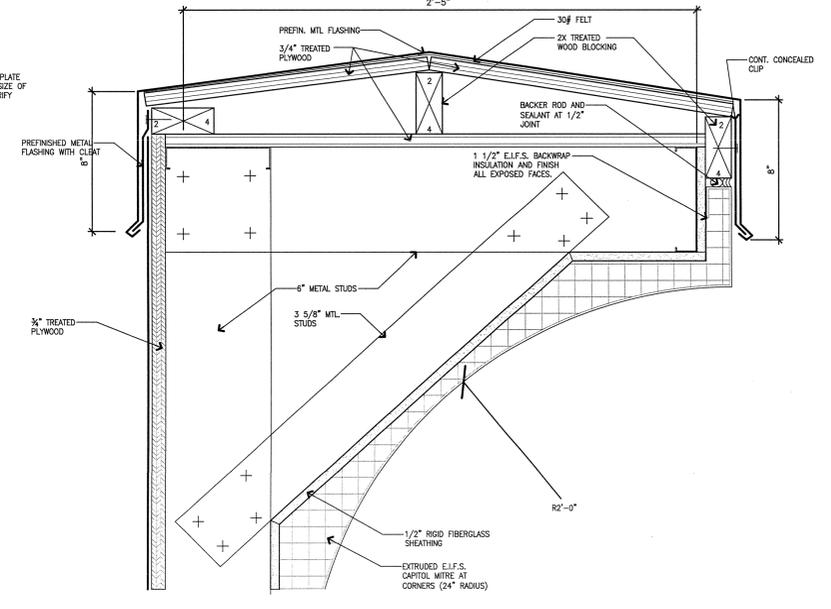


2 Cap Detail  
SCALE: 3\"/>

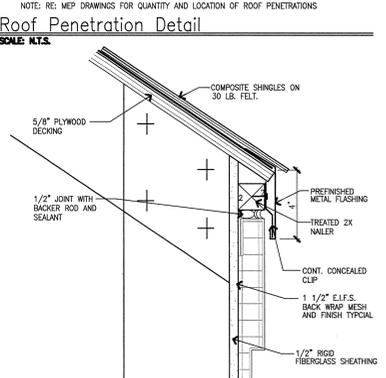


12 Flashing Detail  
SCALE: 3\"/>

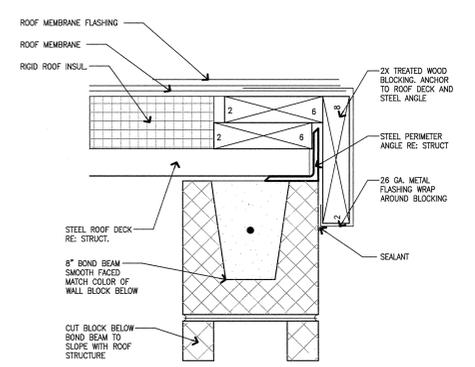


7 Flashing Detail  
SCALE: 3\"/>

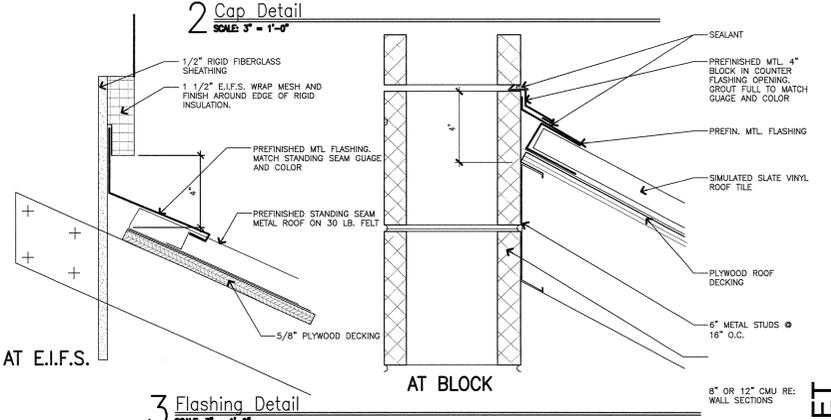


3 Flashing Detail  
SCALE: 3\"/>

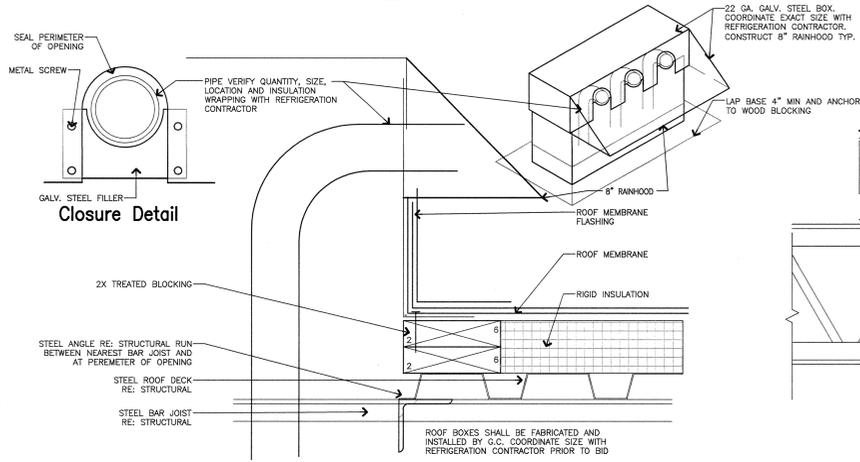


13 Roof Box Detail  
SCALE: N.T.S.

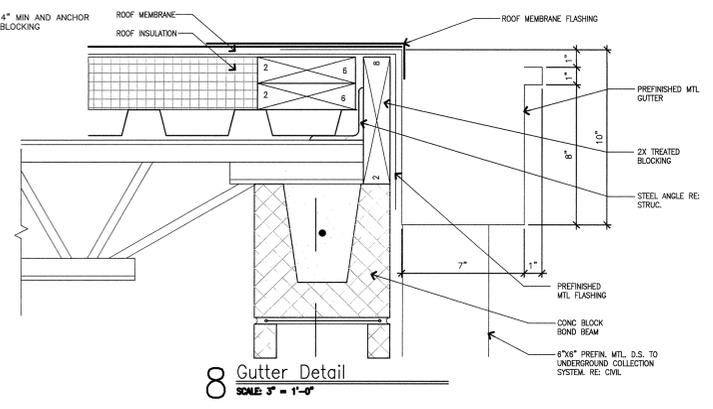

8 Gutter Detail  
SCALE: 3\"/>

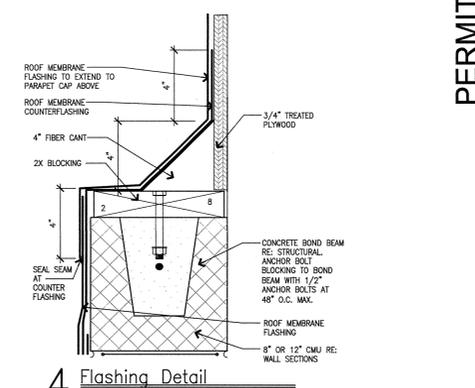

4 Flashing Detail  
SCALE: 3\"/>

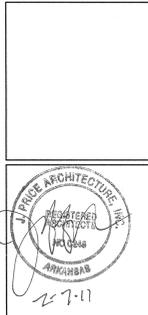

PERMIT SET  
A New Grocery Facility for:  
**Harp's Food Stores (Store # \_\_\_\_\_)**  
Corner of E. Highland Drive and Harrisburg Rd.  
Jonesboro, Arkansas  
© J. Price Architecture, Inc. 2011. All Rights Reserved

ALL SUBCONTRACTORS SHALL BE RESPONSIBLE FOR REVIEWING ALL DRAWINGS IN THE SET PRIOR TO PLACING BID.


REVISIONS:

PROJECT: 103 W Kansas Suite C Liberty, Missouri 64068 (816) 792-5991  
DATE: 10-04-11  
SHEET NUMBER: A5.2




103 W Kansas Suite C Liberty, Missouri 64068 (816) 792-5991


DATE: 10-04-11  
SHEET NUMBER: A5.2

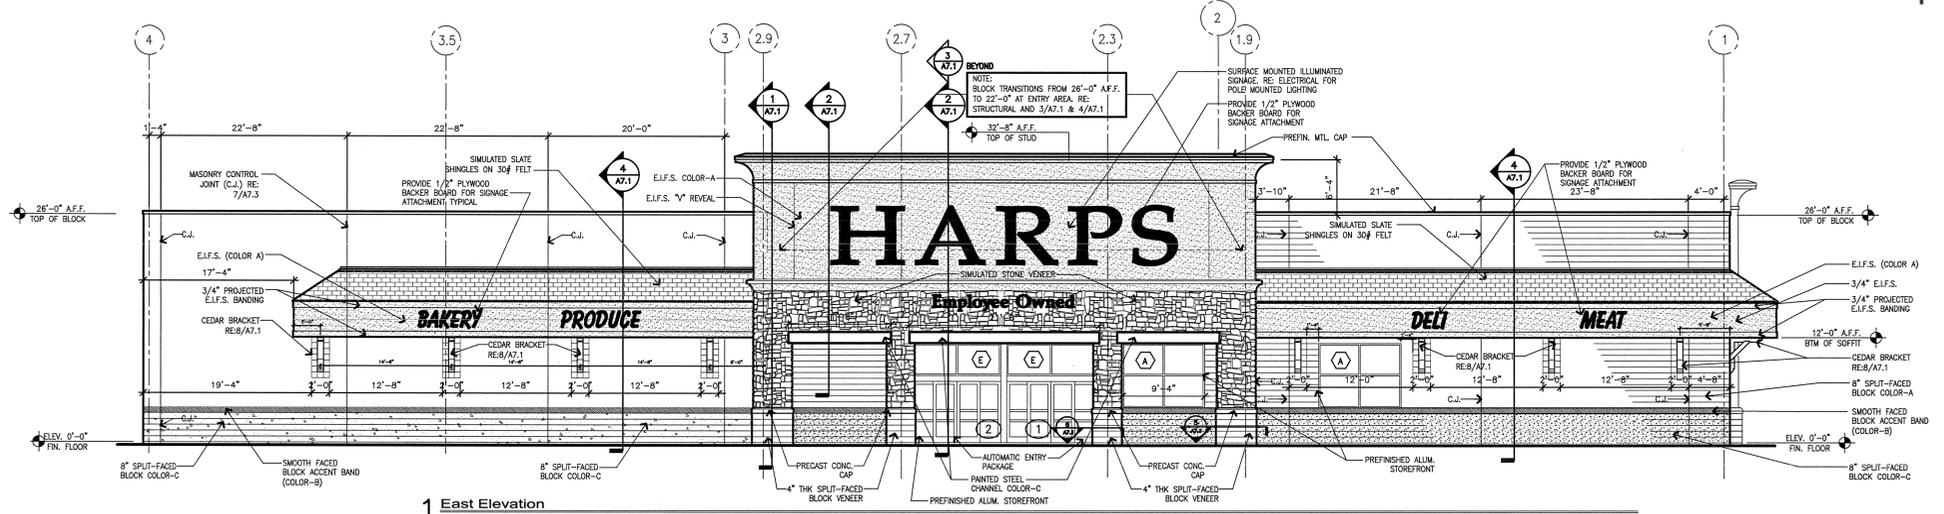


1 East Elevation  
SCALE: 1/8" = 1'-0"

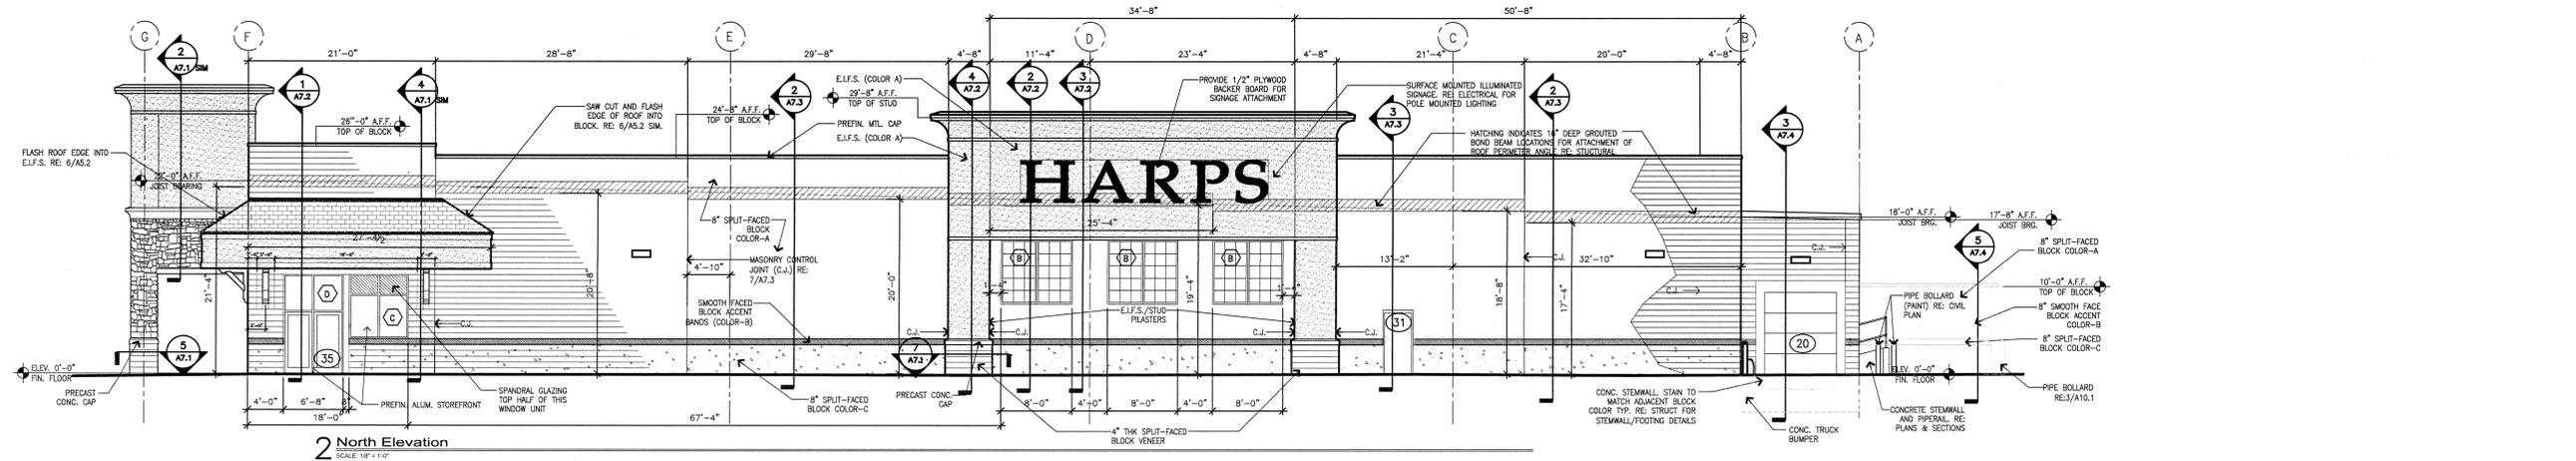


2 North Elevation  
SCALE: 1/8" = 1'-0"

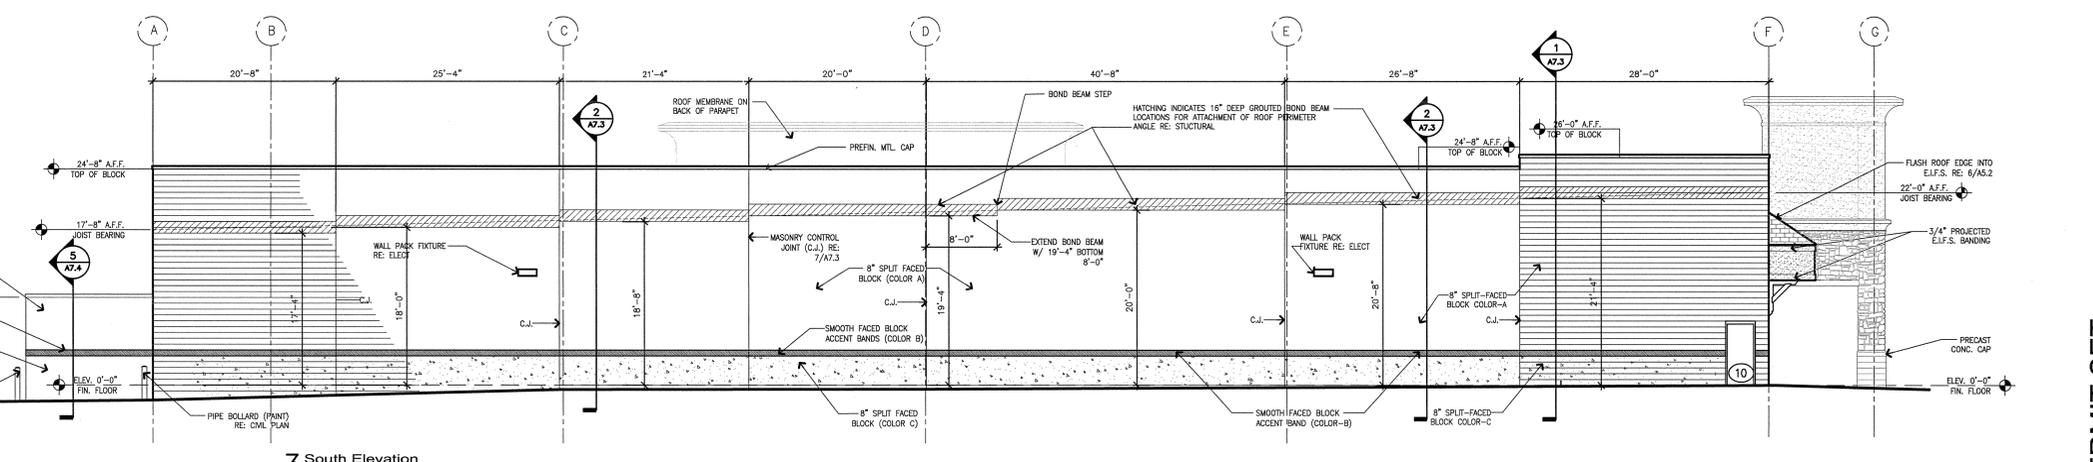

3 South Elevation  
SCALE: 1/8" = 1'-0"

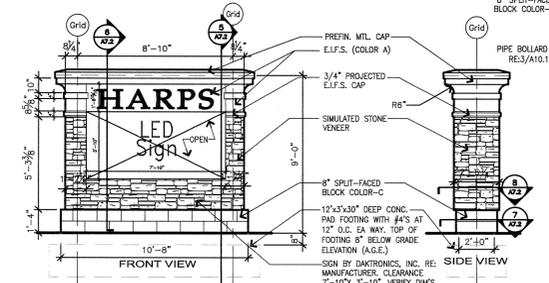


7 Monument Sign Elevations  
SCALE: 1/8" = 1'-0"

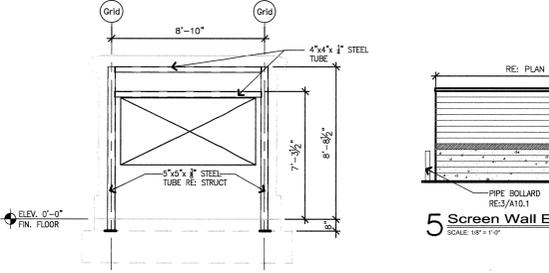

5 Screen Wall Elevations  
SCALE: 1/8" = 1'-0"



6 Monument Sign Steel Elevation  
SCALE: 1/8" = 1'-0"

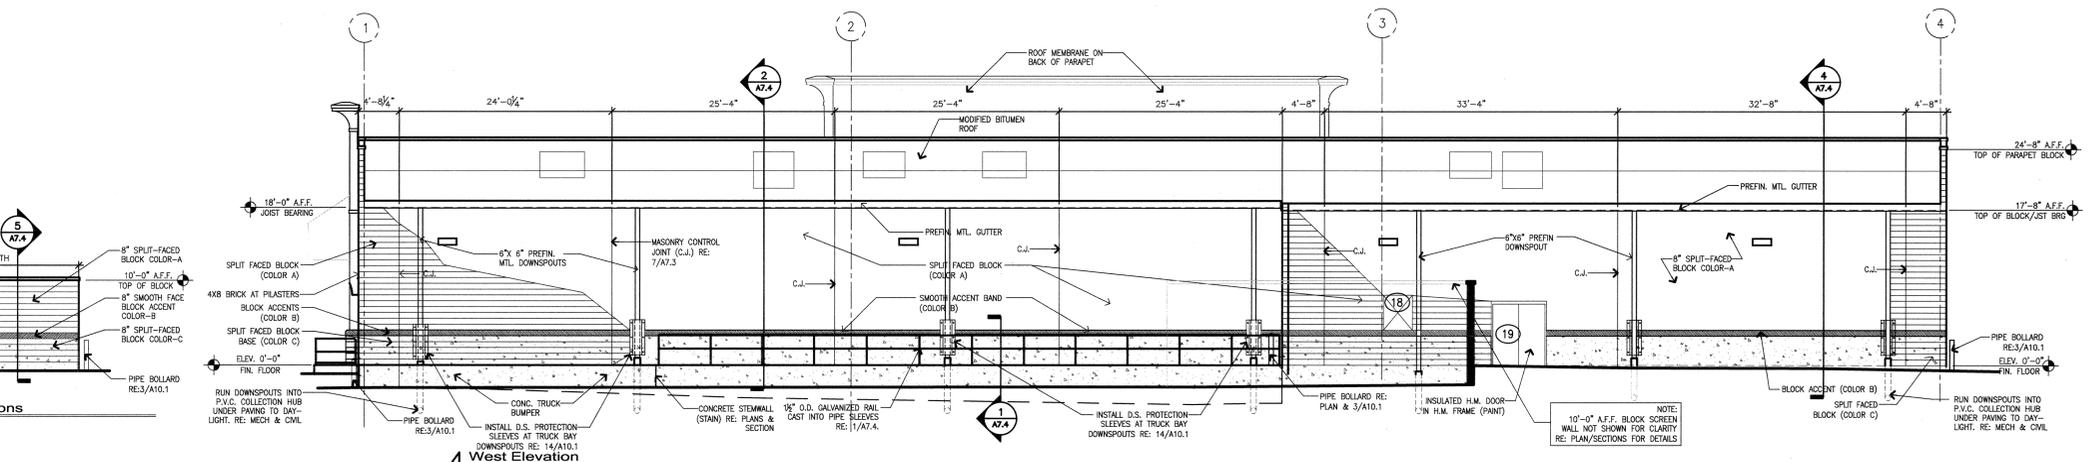

4 West Elevation  
SCALE: 1/8" = 1'-0"

MATERIALS LEGEND	
BLOCK A	MATCH SW6108 "LATTE"
BLOCK B	MATCH SW6106 "KILIM BEIGE"
BLOCK C	MATCH SW6089 "GROUNDED"
E.L.F.S. A	MATCH PAREX #10402 LIMESTONE
E.L.F.S. TEXTURE:	TRIM TEXTURE-"SAND FINE"
	MAIN BODY TEXTURE-"SWIRL FINE"
SIMULATED STONE:	CULTURED STONE "COUNTRY LEDGESTONE" (CSV-20008)
	MORTAR COLOR: MATCH 300 115 YELLOW
PRECAST CONC. CAP:	KELLY CAST STONE (300 115 YELLOW)
	MORTAR COLOR: MATCH 300 115 YELLOW
ROOF SHINGLES:	TAMKO SYNTHETIC SLATE SHINGLES 80% DUSK GRAY, 20% SLATE GREEN
BRACKET COLOR:	MATCH SW6089 "GROUNDED"
ROOF CAP & SHINGLE DRIP:	PACCLAD "SANDSTONE"
FLASHING AT SHINGLES:	PACCLAD "MUSKET GRAY"
COPING OVER E.L.F.S.:	PACCLAD "HUNTER GREEN"
GUTTER AND DOWNSPOUTS:	PACCLAD "SANDSTONE"
COPING OVER BLOCK:	PACCLAD "SANDSTONE"
ALUMINUM STOREFRONT:	"DARK BRONZE"



NOTE: ALL SUBCONTRACTORS SHALL BE RESPONSIBLE FOR REVIEWING ALL DRAWINGS IN THE SET PRIOR TO PLACING BID.

**PERMIT SET**  
A New Grocery Facility for:  
**Harp's Food Stores (Store # )**  
Corner of E. Highland Drive and Harrisburg Rd.  
Jonesboro, Arkansas  
© J. Price Architecture, Inc. 2011. All Rights Reserved




105 W Kansas  
Suite C  
Liberty, Missouri 64068  
(816) 792-5991  
J. PRICE ARCHITECTURE, INC.


REVISIONS:  
DATE: FEBRUARY 02, 2010  
PROJECT: 10-0011  
SHEET NUMBER: **A6.1**

EXTERIOR ELEVATIONS


MATERIAL LEGEND KEY	
2	DIVISION 2: SITEWORK
2A	COMPACTED FILL
2B	GRAVELLY FILL
3	DIVISION 3: CONCRETE & CONCRETE PRODUCTS
3A	REINFORCED CONCRETE SLAB ON GRADE RE: STRUCTURAL
3B	4" THK. 4000 PSI REINFORCED CONCRETE FLOOR W/ LT. BROOM FINISH RE: CIVIL FLOOR
3C	1/2" EXPANSION JOINT MATERIAL WITH POURABLE SEALANT
3D	CONCRETE FOOTING RE: STRUCTURAL
3E	CONCRETE STEM WALL RE: STRUCTURAL
3F	4000 PSI CONC. DOCK PAVING, RE: CIVIL FOR PAVING ELEVATIONS
3G	4000 PSI CONC. CURB, RE: CIVIL
3H	PRECAST CONC. CAP
4	DIVISION 4: MASONRY & MASONRY PRODUCTS
4A	CONCRETE BLOCK BOND BEAM RE: STRUCTURAL FOR REINFORCING
4B	8" THK. SPLIT FACE CONC. BLK. (PAINT) RE: ELEV. FOR COLOR OR 8" THK. SMOOTH CONC. BLK. W/RE: HIDDEN FROM VIEW
4C	8" THK. SMOOTH CENTER SCORE COLOR CONC. BLK. (PAINT) RE: ELEV. FOR COLORS
4D	8" THK. SMOOTH FACED STANDARD COLOR CONC. (PAINT), RE: ELEVATION FOR COLORS
4E	SMALLER STONE VENEER ON METAL LATHE
4F	NOT USED
4G	4" THK. SPLIT FACED CONC. BLOCK (PAINT) RE: ELEVATION FOR COLOR
4H	HORIZ. MASONRY REINFORC. RE: STRUCTURAL
4I	VERTICAL REINFORCEMENT IN GROUTED CELLS RE: STRUCTURAL
4J	16" DEEP BOND BEAM RE: ELEVATIONS FOR LOCATIONS
4K	GROUT FULL BELOW GRADE
4L	MASONRY VENEER ANCHORS AT 16" O.C. EA. WAY
4M	20 MIL. POLY. FLASHING AND WEBS AT 32" O.C.
5	DIVISION 5: STEEL & STEEL PRODUCTS
5A	STEEL TUBE RE: STRUCTURAL (PAINT EXPOSED AREAS)
5B	STEEL ROOF DECK RE: STRUCTURAL
5C	STEEL BAR JOIST RE: STRUCTURAL
5D	STEEL BEAM RE: STRUCTURAL
5E	STEEL ANGLE RE: STRUCTURAL
5F	STEEL CHANNEL RE: ELEVATIONS
5G	STEEL ROOF PLATE RE: STRUCTURAL
5H	STEEL PLATE RE: STRUCTURAL
6	DIVISION 6: WOOD & WOOD PRODUCTS
6A	TREATED WOOD BLOCKING
6B	3/4" THK. TREATED PLYWOOD
6C	5/8" PLYWOOD ROOF DECKING
6D	1/2" EXTERIOR PLYWOOD SHEATHING WITH WEATHER RESISTANT MEMBRANE
6E	2x4 TREATED WOOD STUD @ 16" O.C.
7	DIVISION 7: THERMAL & MOISTURE PROTECTION
7A	PRE-FINISHED METAL CAP WITH CONTINUOUS CLIPS
7B	PRE-FINISHED METAL GUTTER & DOWNSPOUT
7C	PRE-FINISHED METAL FLASHING
7D	10 MIL. VAPOR BARRIER
7E	ROOF MEMBRANE
7F	ROOF MEMBRANE FLASHING, EXTEND UP PARAPET AND UNDER CAP WHERE SHOWN.
7G	RIGID INSULATION
7H	QUALIFIED SUBT CONCRETE CHARGES ON 30# FELT, "WHITE SLATE" BY TAWOZ OR APPROVED EQUAL
7I	2 1/4" E.L.F.S. AT CAP LOCATIONS
7J	4" x 3/4" E.L.F.S. PROJECTION
7K	EXTRUDED E.L.F.S. GASKET
7L	1 1/2" THK. E.L.F.S.
7M	3/4" E.L.F.S.
7N	LAP E.L.F.S. 1/4" AT CORNER FOR CONT. DRIP OR CARVE "Y" GROOVE DRIP
7O	BACK WRAP E.L.F.S. 1/2" FROM ADJACENT SURFACE INSTALL CLOSED CELL BACKER BOARD AND SEAL (TYPICAL)
7P	CONC. 3" VENT IN RIDG. FIBERGLASS SHEATHING, BACK WRAP E.L.F.S. AT AT VENT. SEAL, GASK. AND PAINT VENT TO MATCH GP.
7Q	FORMED INSULATION IN BLOCK CELLS
7R	SEAL ALL EXPOSED MASONRY TYPICAL WITH CLEAR SEALER
7S	FIBRE GAIT ON TREATED WOOD BLOCKING (ONLY REQUIRED IF WOODEN BEAM/ROOF OFFER & GASKET)
7T	6" R-19 FIBERGLASS INSULATION
7U	PRE-FINISHED STANDING SEAM METAL ROOFING ON 30 LB FELT
7V	PRE-FINISHED METAL DRIP
7W	WEATHER RESISTANT MEMBRANE WRAP
8	DIVISION 8: DOORS & WINDOWS
8A	ALUMINUM STOREFRONT
8B	AUTOMATIC DRYER PROGRADE
8C	SECTIONAL METAL OVERHEAD DOOR
9	DIVISION 9: FINISHES
9A	5/8" TYPE "X" GYPSUM BOARD (PAINT)
9B	1/2" RIGID FIBERGLASS SHEATHING
9C	6" METAL STUDS AT 16" O.C.
9D	3 5/8" METAL STUDS AT 16" O.C.
9E	7/8" HD CHANNELS
9F	2 1/2" METAL STUDS AT 16" O.C.
9G	LAY-IN CEILING RE: REFLECTED CEILING PLAN
9H	METAL CORNER BEAD
9I	1/2" CEMENTITIOUS BACKER BOARD FOR ALL TILE WALLS IN TOILET ROOMS.
9J	THE FINISH RE: FINISH SCHEDULE AND TOILET ROOM ELEVATIONS.
10	DIVISION 10: SPECIAL CONSTRUCTION
10A	DRYWALL WALL PANELS SECURED TO HAT CHANNELS

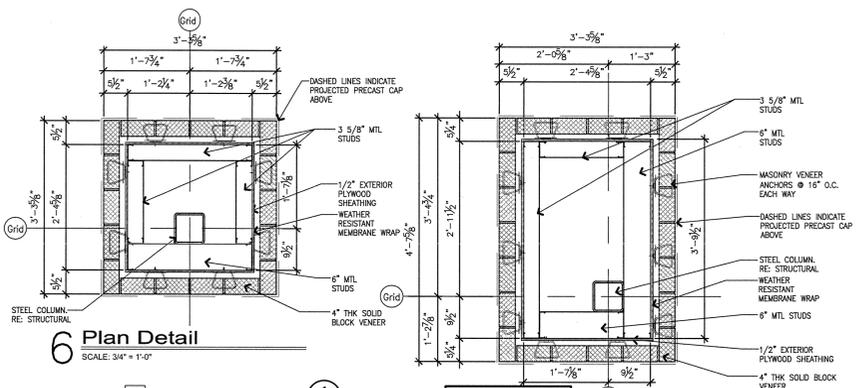

**5 Plan Detail**  
SCALE: 3/4" = 1'-0"

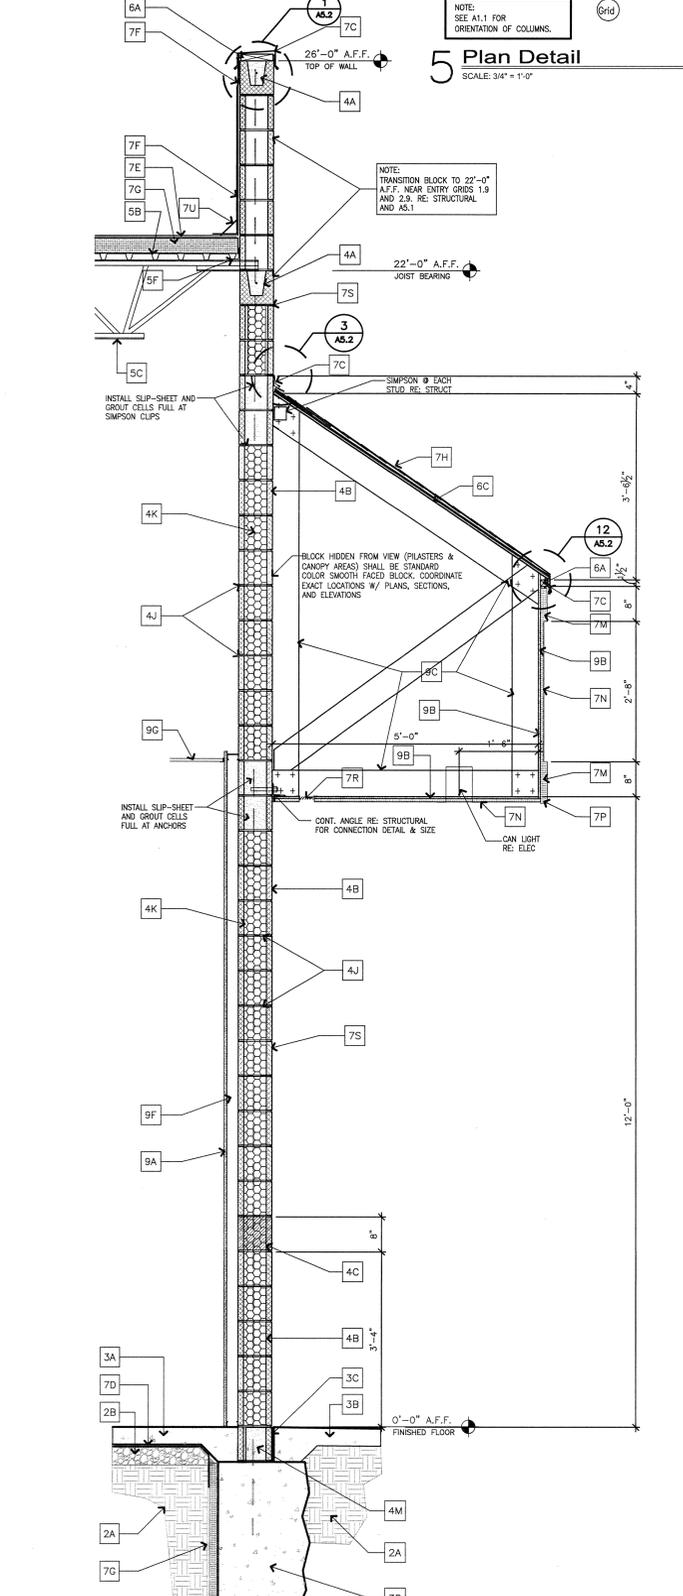


**4 Wall Section**  
SCALE: 3/4" = 1'-0"

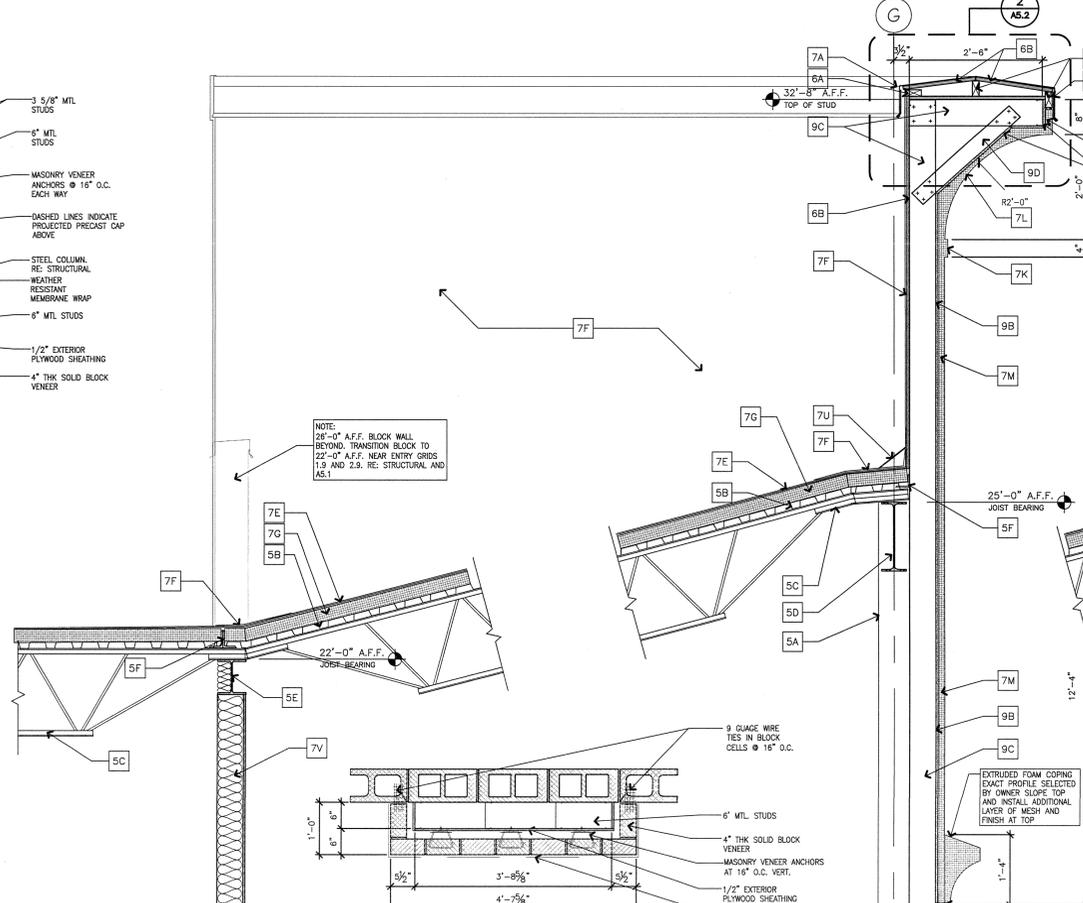


**2 Wall Section**  
SCALE: 3/4" = 1'-0"

**7 Plan Detail**  
SCALE: 3/4" = 1'-0"

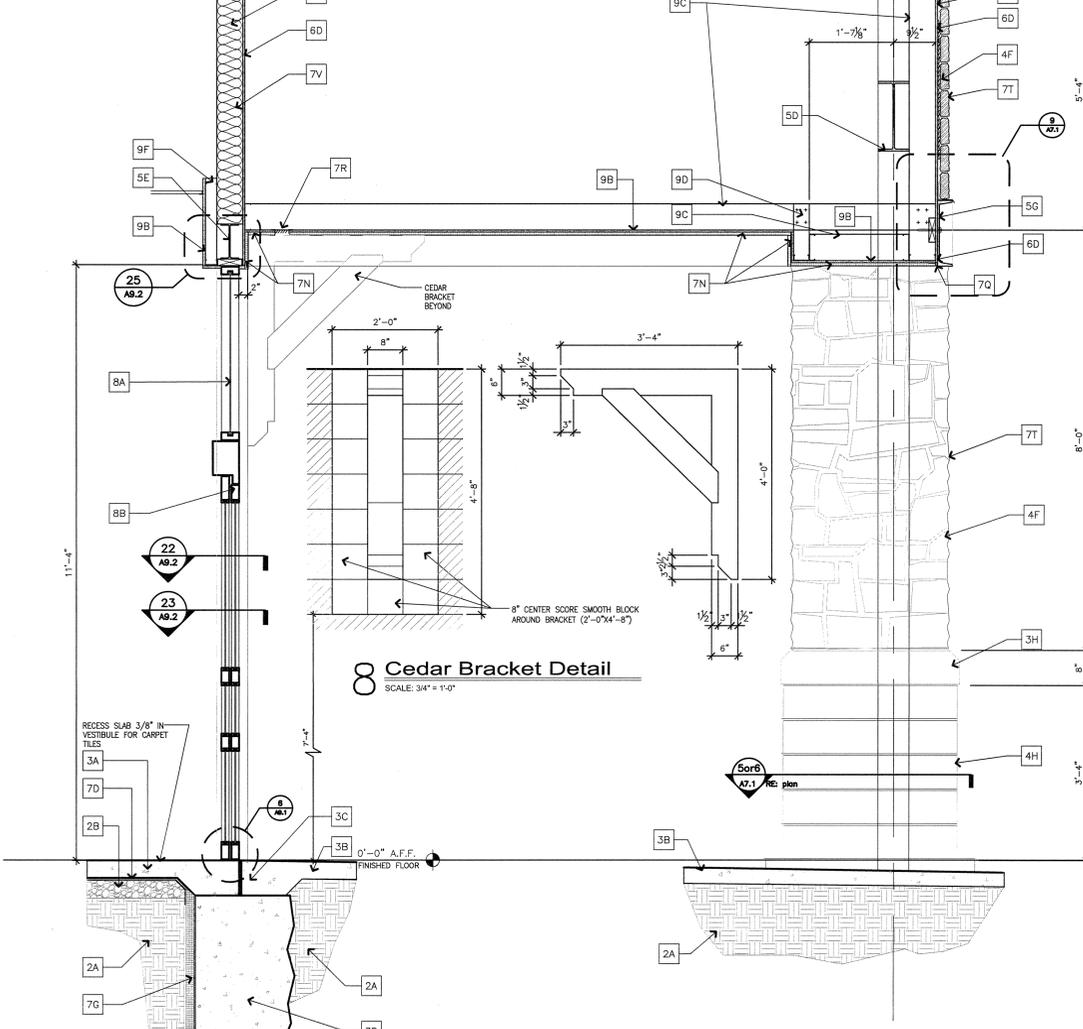


**3 Wall Section**  
SCALE: 3/4" = 1'-0"


**8 Cedar Bracket Detail**  
SCALE: 3/4" = 1'-0"

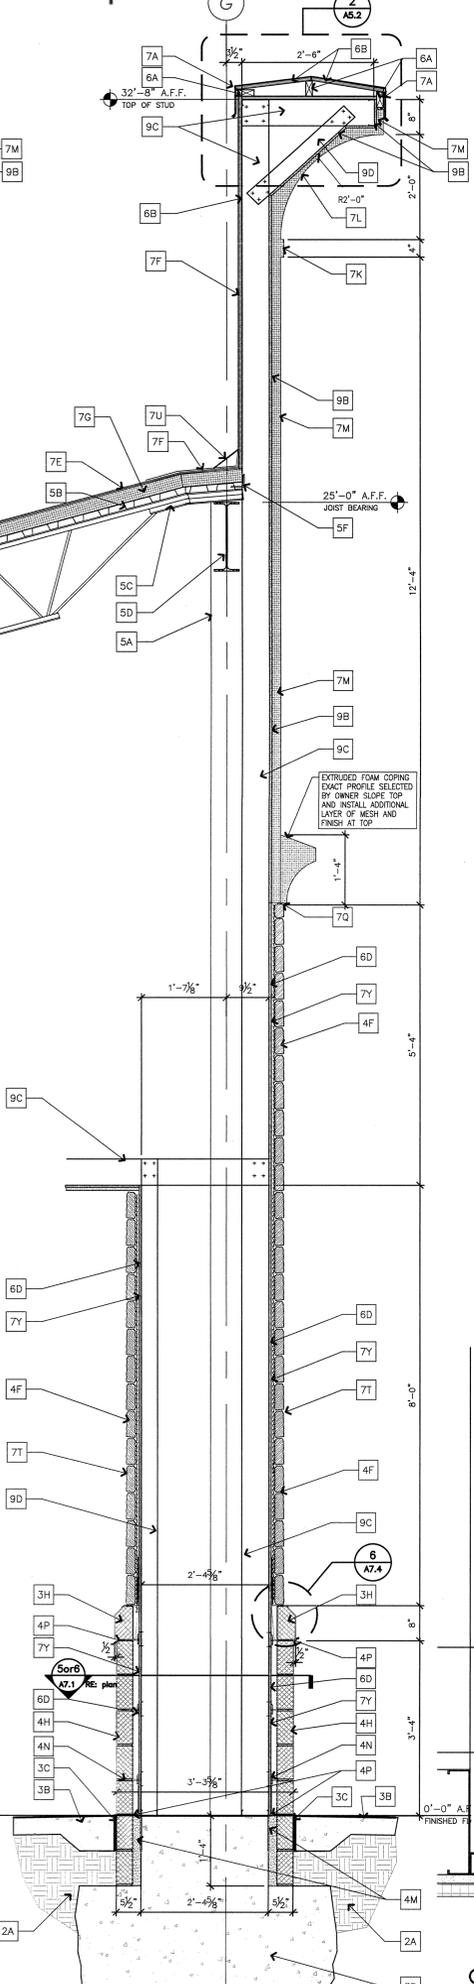

**1 Wall Section**  
SCALE: 3/4" = 1'-0"

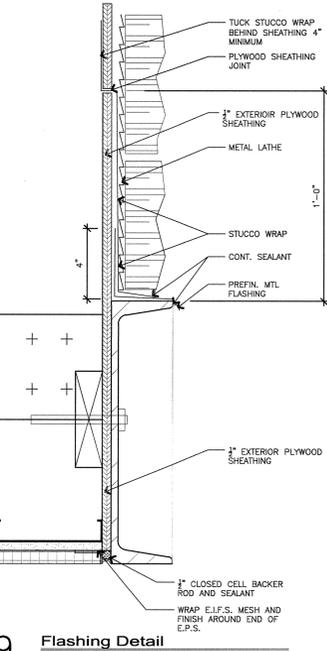

**9 Flashing Detail**  
3/4" = 1'-0"

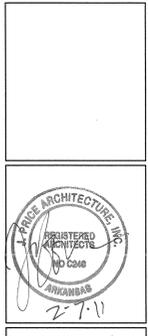

NOTE: ALL SUBCONTRACTORS SHALL BE RESPONSIBLE FOR REVIEWING ALL DRAWINGS IN THE SET PRIOR TO PLACING BID.

**PERMIT SET**  
A New Grocery Facility for:  
**Harp's Food Stores (Store # \_\_\_\_\_)**  
Corner of E. Highland Drive and Harrisburg Rd.  
Jonesboro, Arkansas  
© J. Price Architecture, Inc. 2011 All Rights Reserved



105 W Kansas  
Suite C  
Liberty, Missouri 64068  
(816) 792-5991









REVISIONS:

EXTERIOR WALL SECTIONS  
DATE: FEBRUARY 02, 2010  
PROJECT: PERMIT SET  
SHEET NUMBER: **A7.1**

2	<b>DIVISION 2: SITING</b>
2A	COMPACTED FILL
2B	GRAVELLY FILL
3	<b>DIVISION 3: CONCRETE &amp; CONCRETE PRODUCTS</b>
3A	REINFORCED CONCRETE SLAB ON GRADE RE. STRUCTURAL
3B	4" THK. 4000 PSI REINFORCED CONCRETE PAVING W/ LT. BROOM FINISH RE. CIVIL
3C	1/2" EXPANSION JOINT MATERIAL WITH POINABLE SEALANT
3D	CONCRETE FOOTING RE. STRUCTURAL
3E	CONCRETE STEM WALL RE. STRUCTURAL
3F	4000 PSI CONC. DOCK PAVING RE. CIVIL FOR PAVING ELEVATIONS
3G	4000 PSI CONC. CURB RE. CIVIL
3H	PRECAST CONC. CAP
4	<b>DIVISION 4: MASONRY &amp; MASONRY PRODUCTS</b>
4A	CONCRETE BLOCK BOND BEAM RE. STRUCTURAL FOR RENT
4B	8" THK. SPLIT FACE CONC. BLK. (PAINT) RE. ELEV. FOR COLOR OR 8" THK. SMOOTH CONC. BLK. (PAINT) RE. ELEV. FOR COLOR OR 8" THK. SMOOTH CENTER SCORE COLOR CONC. BLK. (PAINT) RE. ELEV. FOR COLORS
4C	NOT USED
4D	8" THK. SMOOTH FACED STANDARD COLOR BLOCK (PAINT) RE. ELEVATION FOR COLORS
4E	SMALLER STONE VENEER ON METAL LATH
4F	NOT USED
4G	4" THICK SPLIT FACED CONC. BLOCK (PAINT) RE. ELEVATION FOR COLOR
4H	HORIZ. MASONRY REIN. RE. STRUCTURAL
4I	VERTICAL REINFORCEMENT IN GROUTED CELLS RE. STRUCTURAL
4J	15" DEEP BOND BEAM RE. ELEVATIONS FOR LOCATIONS
4K	GROUT FULL BELOW GRADE
4L	MASONRY VENEER ANCHORS AT 16" O.C. EA. WAY
4M	20 ML. POLY FLASHING AND WEEPS AT 32" O.C.
5	<b>DIVISION 5: STEEL &amp; STEEL PRODUCTS</b>
5A	STEEL TUBE RE. STRUCTURAL (PAINT EXPOSED AREAS)
5B	STEEL ROOF DECK RE. STRUCTURAL
5C	STEEL BAR JOIST RESTRUCTURAL
5D	STEEL BEAM RE. STRUCTURAL
5E	STEEL BEAM / PLATE LITTLE (PAINT)
5F	STEEL ANGLE RE. STRUCTURAL
5G	STEEL CHANNEL RE. ELEVATIONS
5H	STEEL BENT PLATE RE. STRUCTURAL
5I	STEEL PLATE RE. STRUCTURAL
6	<b>DIVISION 6: WOOD &amp; WOOD PRODUCTS</b>
6A	TREATED WOOD BLOCKING
6B	5/4" THK. TREATED PLYWOOD
6C	5/8" PLYWOOD ROOF DECKING
6D	1/2" EXTERIOR PLYWOOD SHEATHING WITH WEATHER RESISTANT MEMBRANE
6E	2x4 TREATED WOOD STUD @ 16" O.C.
7	<b>DIVISION 7: THERMAL &amp; MOISTURE PROTECTION</b>
7A	PRE-FINISHED METAL CAP WITH CONTINUOUS CLIPS
7B	PRE-FINISHED METAL GUTTER & DOWNSPOUT
7C	PRE-FINISHED METAL FLASHING
7D	10 ML. VAPOR BARRIER
7E	ROOF MEMBRANE FLASHING. EXTEND UP PARAPET AND UNDER CAP WHERE SHOWN.
7F	ROOF INSULATION
7G	SMALLER STONE VENEER ON 3/4" FIB. "RAMMIE SLATE" BY TAYLOR OF APPROVED EQUAL
7H	2 1/4" E.L.F.S. AT CAP LOCATIONS
7I	4" x 3/4" E.L.F.S. PRODUCTION
7J	EXTRUDED E.L.F.S. COPING
7K	1 1/2" THK. E.L.F.S.
7L	3/4" E.L.F.S.
7M	LAP E.L.F.S. 1/4" AT CORNER FOR CONT. DRIP OR CANE "Y" GROOVE DRIP
7N	BACK WOOD E.L.F.S. 1/2" FROM ADJACENT SURFACE INSTALL CLOSED CELL BARRIER ROD AND SEAL (TYPICAL)
7O	CONT. 3" VENT IN ROOF FIBERGLASS SHEATHING. BACK WRAP E.L.F.S. AT 4" VENT. SEAL. DOCK AND PANE 16" TO MATCH DRIP.
7P	FORMED INSULATION IN BLOCK CELLS
7Q	SEAL ALL EXPOSED MASONRY TYPICAL WITH CLEAR SEALER
7R	FIBRE CANT ON TREATED WOOD BLOCKING (ONLY REQUIRED IF MODIFIED SHOWN ROOF OPTION IS CHOSEN)
7S	8" R-19 FIBERGLASS INSULATION
7T	PRE-FINISHED STANDING SEAM METAL ROOFING ON 30 LB FELT
7U	WEATHER RESISTANT MEMBRANE WRAP
8	<b>DIVISION 8: DOORS &amp; WINDOWS</b>
8A	ALUMINUM STOREFRONT
8B	ADJUSTABLE DOOR FRAME
8C	SECTIONAL METAL OVERHEAD DOOR
9	<b>DIVISION 9: FINISHES</b>
9A	5/8" TYPE "X" OPSISUM BOARD (PAINT)
9B	1/2" ROOF FIBERGLASS SHEATHING
9C	8" METAL STUDS AT 16" O.C.
9D	3 5/8" METAL STUDS AT 16" O.C.
9E	7/8" HD DIMENSION
9F	2 1/2" METAL STUDS AT 16" O.C.
9G	LAY-IN CEILING RE. REFLECTED CEILING PLAN
9H	METAL CORNER BEAD
9I	1/2" CEMENTITIOUS BACKER BOARD FOR ALL TILE WALLS IN TOILET ROOMS.
9J	THE FINISH RE. FINISH SCHEDULE AND TOILET ROOM ELEVATIONS.
10	<b>DIVISION 13: SPECIAL CONSTRUCTION</b>
10A	CHAROLINE WALL PANELS SECURED TO HW CHANNELS



NOTE: ALL SUBCONTRACTORS SHALL BE RESPONSIBLE FOR REVIEWING ALL DRAWINGS IN THE SET PRIOR TO PLACING BID.

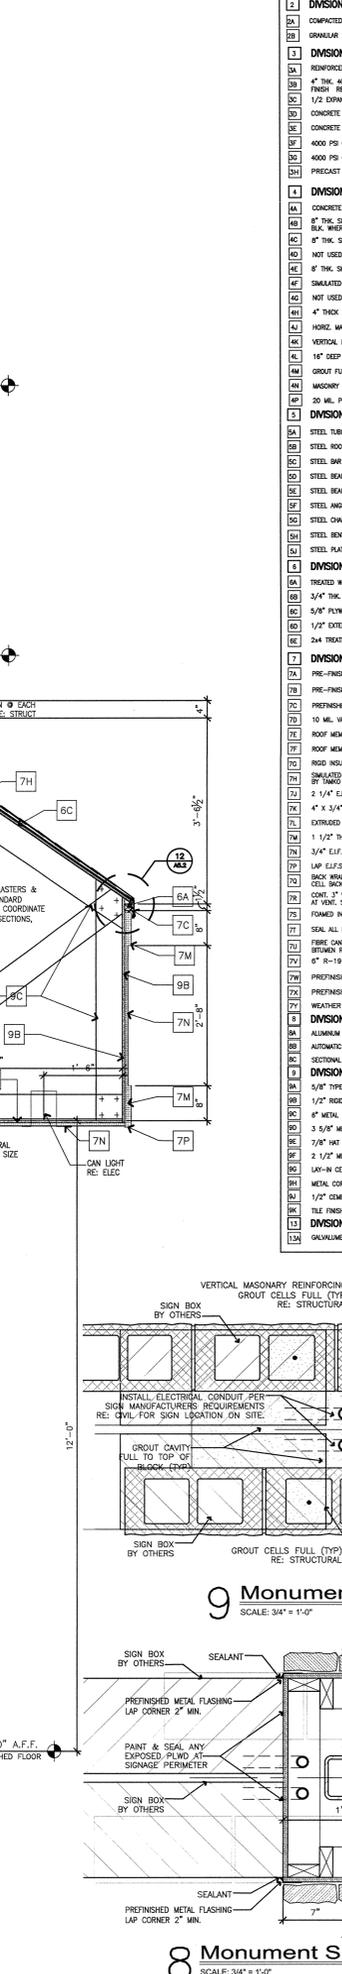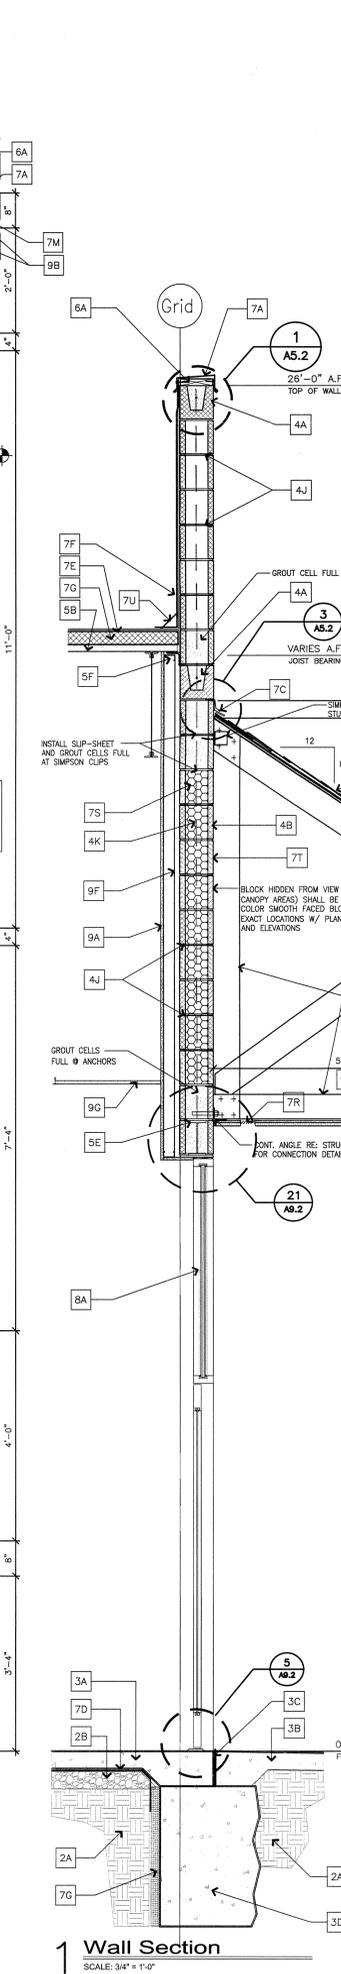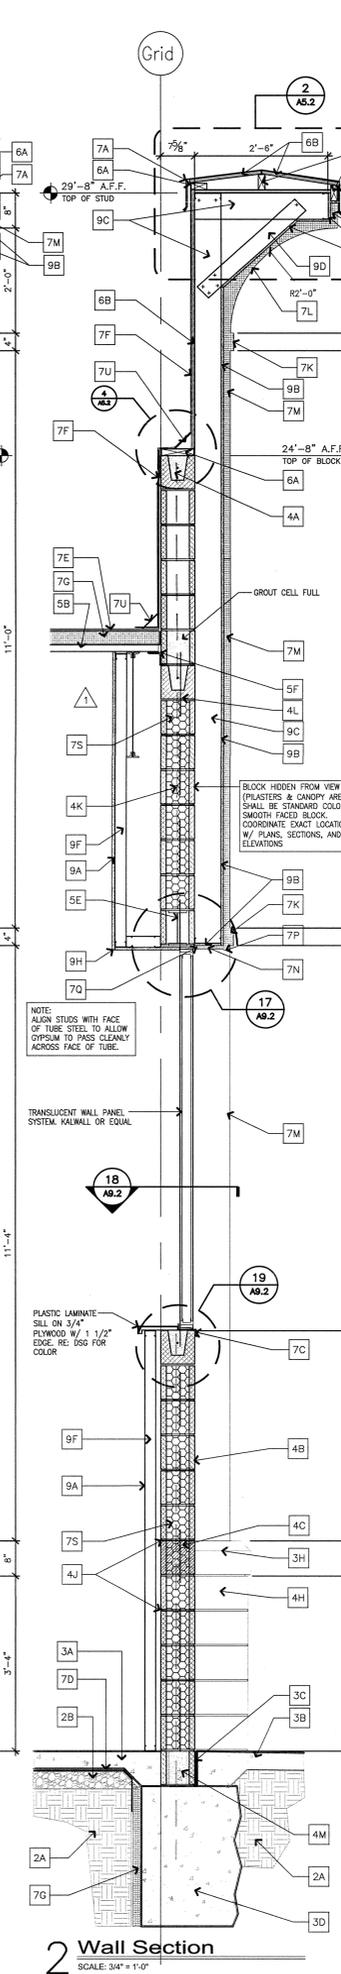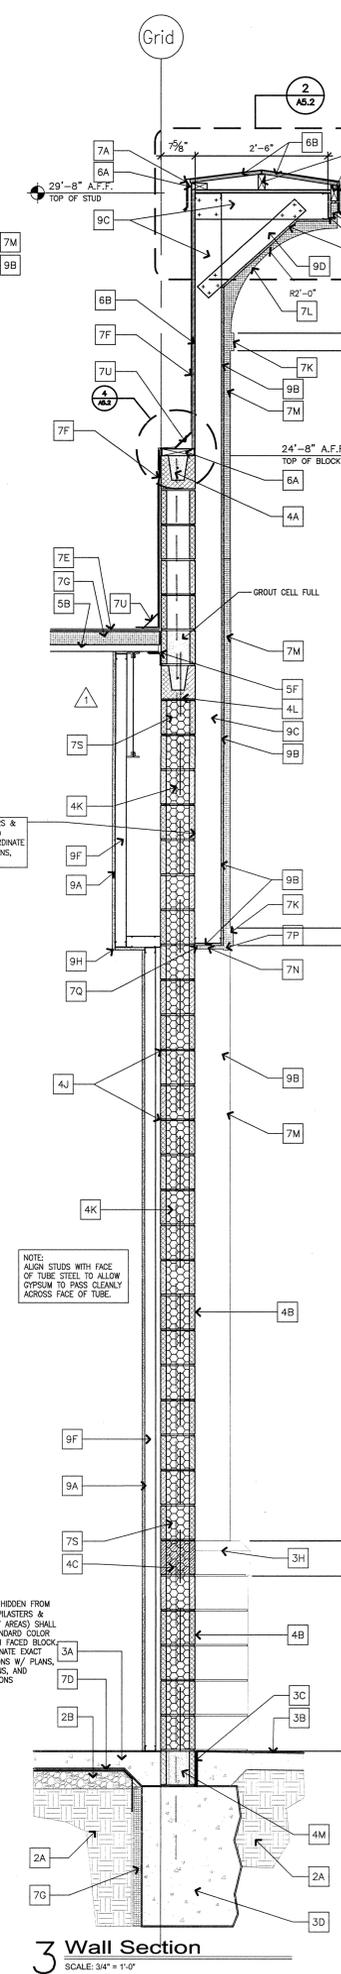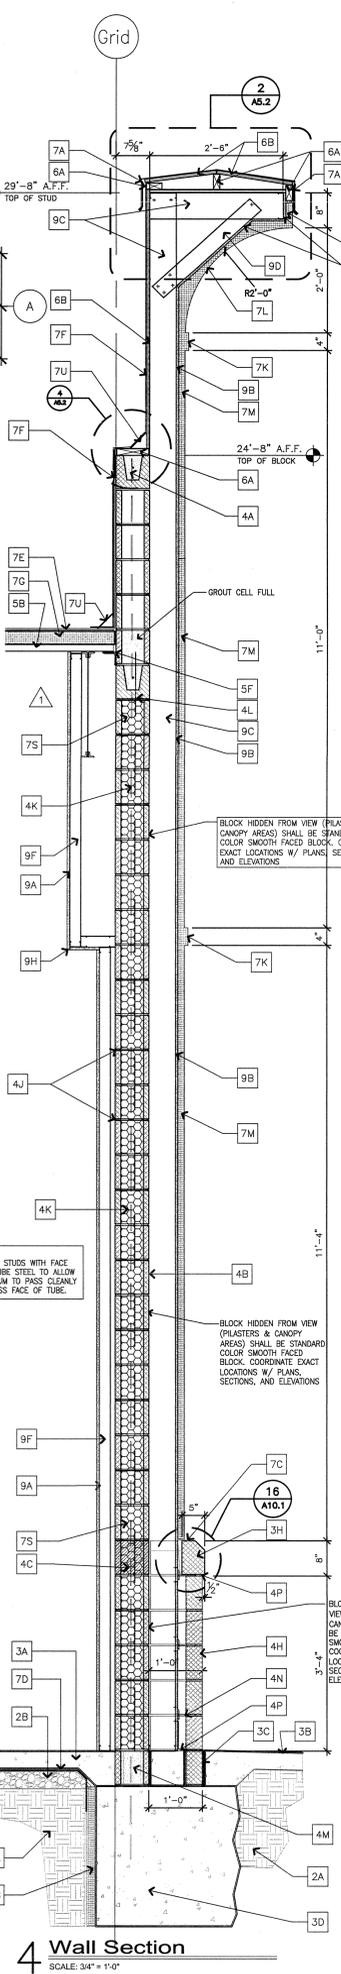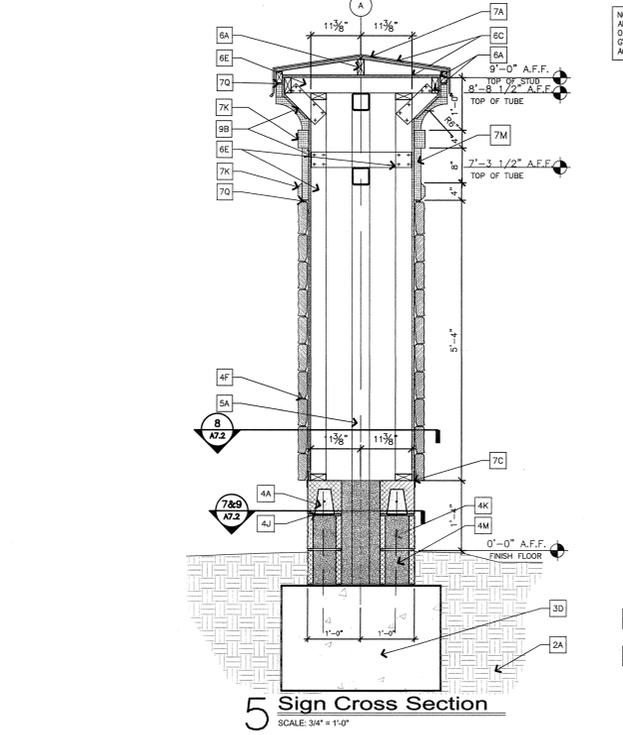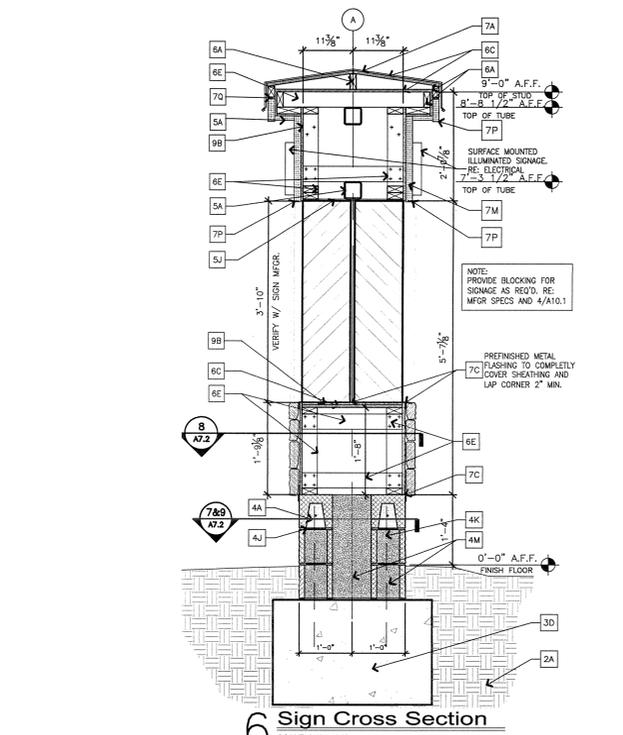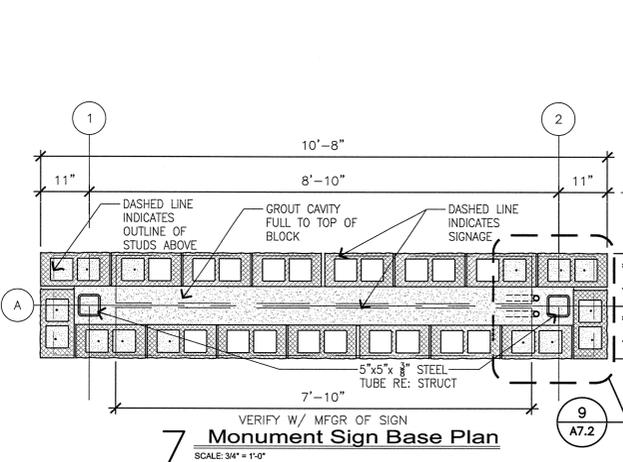

PERMIT SET  
A New Grocery Facility for:  
**Harp's Food Stores (Store # \_\_\_\_\_)**  
Corner of E. Highland Drive and Harrisburg Rd.  
Jonesboro, Arkansas  
© J. Price Architects, Inc. 2011. All Rights Reserved





105 W Kansas  
Suite C  
Liberty, Missouri 64068  
(816) 792-5991  
REVISIONS:  
EXTERIOR WALL SECTIONS  
DATE: FEBRUARY 02, 2010  
PROJECT: 10-0441  
SHEET NUMBER: **A7.2**

MATERIAL LEGEND KEY

<b>DIVISION 2: SITEWORK</b>	
2A	COMPACTED FILL
2B	GRAVEL FILL
<b>DIVISION 3: CONCRETE &amp; CONCRETE PRODUCTS</b>	
3A	REINFORCED CONCRETE SLAB ON GRADE RE. STRUCTURAL
3B	4" THK. 4000 PSI REINFORCED CONCRETE PAVING W/ LT. BROOM FINISH RE. CIVIL PAVING
3C	1/2" EXPANSION JOINT MATERIAL WITH POORABLE SEALANT
3D	CONCRETE FOOTING RE. STRUCTURAL
3E	CONCRETE STEM WALL RE. STRUCTURAL
3F	4000 PSI CONC. DOCK PAVING, RE. CIVIL FOR PAVING ELEVATIONS
3G	4000 PSI CONC. CURB, RE. CIVIL
3H	PRECAST CONC. CAP
<b>DIVISION 4: MASONRY &amp; MASONRY PRODUCTS</b>	
4A	CONCRETE BLOCK BOND BEAM RE. STRUCTURAL FOR REIN.
4B	8" THK. SPLIT FACE CONC. BLK. (PAINT) RE. ELEV. FOR COLOR OR 8" THK. SMOOTH CONC. BLK. W/SEAL HOOKS FROM REIN.
4C	8" THK. SMOOTH CENTER SCORE COLOR CONC. BLK. (PAINT) RE. ELEV. FOR COLORS
4D	NOT USED
4E	8" THK. SMOOTH FACED STANDARD COLOR BLOCK (PAINT), RE. ELEVATION FOR COLORS
4F	SMALLER STONE VENEER ON METAL LATH
4G	NOT USED
4H	4" THK. SPLIT FACE CONC. BLOCK (PAINT) RE. ELEVATION FOR COLOR
4I	HORIZ. MASONRY REIN. RE. STRUCTURAL
4J	VERTICAL REINFORCEMENT IN GROUTED CELLS RE. STRUCTURAL
4K	14" DEEP BOND BEAM RE. ELEVATIONS FOR LOCATIONS
4L	GROUT FULL GRADE
4M	MASONRY VENEER ANCHORS AT 18" O.C. EA. WAY
4N	20 MIL. POLY. FLASHING AND WEEDS AT 3/2" O.C.
<b>DIVISION 5: STEEL &amp; STEEL PRODUCTS</b>	
5A	STEEL TUBE RE. STRUCTURAL (PAINT EXPOSED AREAS)
5B	STEEL ROOF DECK RE. STRUCTURAL
5C	STEEL BAR JOIST RE.STRUCTURAL
5D	STEEL BEAM RE. STRUCTURAL
5E	STEEL BEAM / PLATE LATH (PAINT)
5F	STEEL WARE RE. STRUCTURAL
5G	STEEL CHANNEL, RE. ELEVATIONS
5H	STEEL BOAT PLATE RE. STRUCTURAL
5I	STEEL PLATE RE. STRUCTURAL
<b>DIVISION 6: WOOD &amp; WOOD PRODUCTS</b>	
6A	TREATED WOOD BLOCKING
6B	1/4" THK. TREATED PLYWOOD
6C	5/8" PLYWOOD ROOF DECKING
6D	1/2" EXTERIOR PLYWOOD SHEATHING WITH WEATHER RESISTANT MEMBRANE
6E	2x4 TREATED WOOD STUD @ 16" O.C.
<b>DIVISION 7: THERMAL &amp; MOISTURE PROTECTION</b>	
7A	PRE-FINISHED METAL CAP WITH CONTINUOUS CLIPS
7B	PRE-FINISHED METAL GUTTER & DOWNSPOUT
7C	PRE-FINISHED METAL FLASHING
7D	10 MIL. VAPOR BARRIER
7E	ROOF MEMBRANE
7F	ROOF MEMBRANE FLASHING, EXTEND UP PARAPET AND UNDER CAP WHERE SHOWN.
7G	ROOF INSULATION
7H	SMALLER STONE COMPOSITE GRANULES ON 3/8" FILL, "DAMPWIRE SLAT" BY BRAND OR APPROVED EQUAL
7I	2 1/4" E.L.F.S. AT CAP LOCATIONS
7J	4" x 3/4" E.L.F.S. PROJECTION
7K	OUTRIGGED E.L.F.S. CONTROL
7L	1 1/2" THK. E.L.F.S.
7M	3/4" E.L.F.S.
7N	LAP E.L.F.S. 1/4" AT CORNER FOR CONT. DRIP OR CARVE "Y" GROOVE DRIP
7O	BACK WRAP E.L.F.S. 1/2" FROM ADJACENT SURFACE INSTALL CLOSED CELL BACKER ROD AND SEAL TYPICAL
7P	CONT. 3" VENT IN ROOF FIBERGLASS SHEATHING, BACK WRAP E.L.F.S. AT 4" VENT, SEAL, SIDE AND PANT VENT TO MATCH GYP.
7Q	FORMED INSULATION IN BLOCK CELLS
7R	SEAL ALL EXPOSED MASONRY TYPICAL WITH CLEAR SEALER
7S	FIBRE COTE ON TREATED WOOD BLOCKING (ONLY REQUIRED IF MODIFIED STRAIN ROOF OPTION IS CHOSEN)
7T	6" R-19 FIBERGLASS INSULATION
7U	PRE-FINISHED STANDING SEAM METAL ROOFING ON 3/8" LB FELT
7V	PRE-FINISHED METAL DRIP
7W	WEATHER RESISTANT MEMBRANE WRAP
<b>DIVISION 8: DOORS &amp; WINDOWS</b>	
8A	ALUMINUM STOREFRONT
8B	AUTOMATIC DRY PACKAGE
8C	SECTIONAL METAL OVERHEAD DOOR
<b>DIVISION 9: FINISHES</b>	
9A	5/8" TYPE "X" GYPSUM BOARD (PAINT)
9B	1/2" ROOF FIBERGLASS SHEATHING
9C	6" METAL STUDS AT 18" O.C.
9D	3 5/8" METAL STUDS AT 18" O.C.
9E	2 7/8" MET. CHANNELS
9F	2 1/2" METAL STUDS AT 18" O.C.
9G	LAY-IN CEILING RE. REFLECTED CEILING PLAN
9H	METAL CORNER BEAD
9I	1/2" CEMENTITIOUS BACKER BOARD FOR ALL TILE WALLS IN TOILET ROOMS
9J	TILE FINISH RE. FINISH SCHEDULE AND TOILET ROOM ELEVATIONS.
<b>DIVISION 13: SPECIAL CONSTRUCTION</b>	
13A	CALCULATED WALL PANELS SECURED TO HWY CHANNELS






NOTE: ALL SUBCONTRACTORS SHALL BE RESPONSIBLE FOR REVIEWING ALL DRAWINGS IN THE SET PRIOR TO PLACING BID.

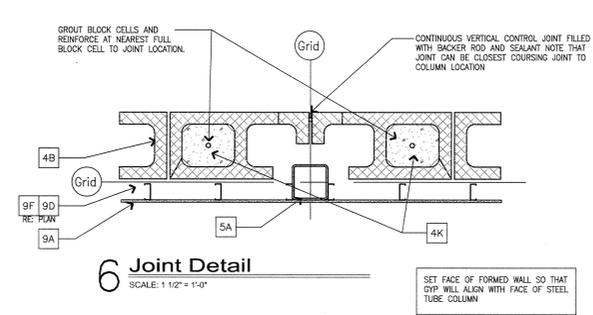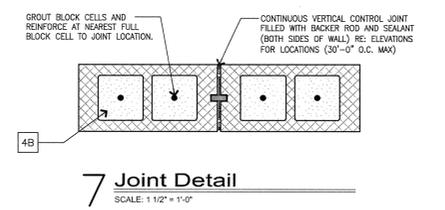

5 NOT USED  
SCALE: 3/4" = 1'-0"

4 NOT USED  
SCALE: 3/4" = 1'-0"

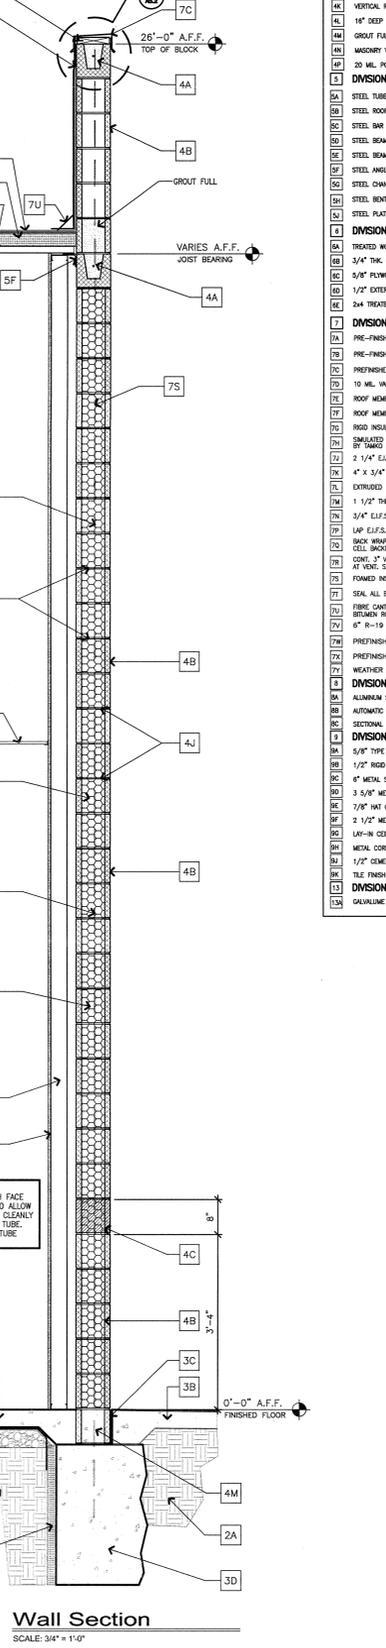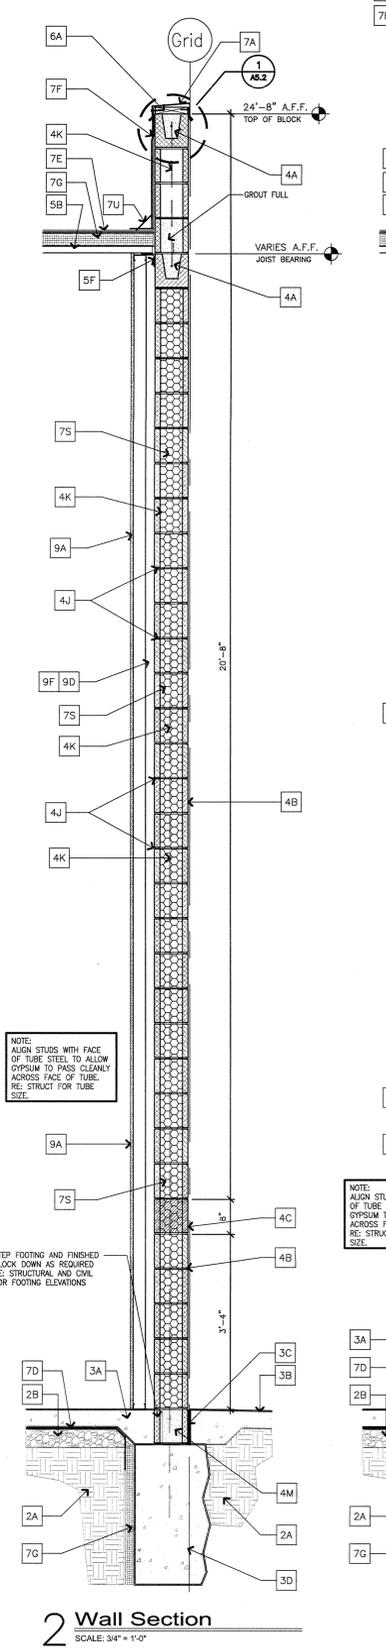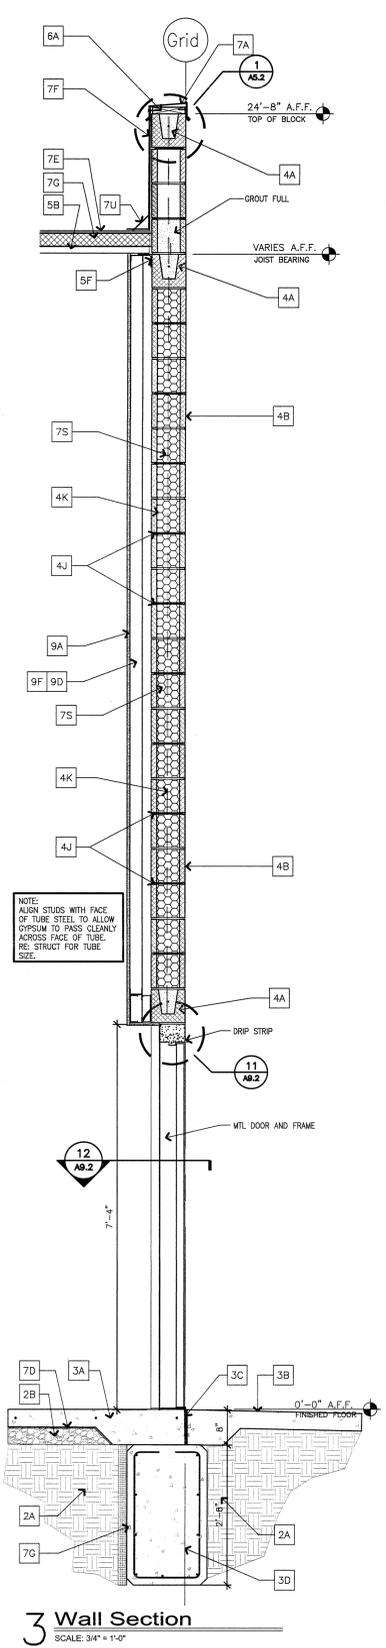

PERMIT SET

A New Grocery Facility for:  
**Harp's Food Stores (Store # \_\_\_\_\_)**  
Corner of E. Highland Drive and Harrisburg Rd.  
Jonesboro, Arkansas  
© J. Price Architecture, Inc. 2011 All Rights Reserved



105 W Kansas  
Suite C  
Liberty, Missouri 64068  
(816) 792-9991


EXTERIOR WALL SECTIONS	DATE: FEBRUARY 07, 2010	A7.3
PROJECT: 09-041	SHEET NUMBER:	

MATERIAL LEGEND KEY

1	DIVISION 2: SITEWORK
2A	COMPACTED FILL
2B	GRAVELLAR FILL
3	DIVISION 3: CONCRETE & CONCRETE PRODUCTS
3A	REINFORCED CONCRETE SLAB ON GRADE RE. STRUCTURAL
3B	4" THK. 4000 PSI REINFORCED CONCRETE PAVING W/ LT. BROOM FINISH RE. CIVIL PAVING
3C	1/2" EXPANSION JOINT MATERIAL WITH POURABLE SEALANT
3D	CONCRETE FOOTING RE. STRUCTURAL
3E	CONCRETE STEM WALL RE. STRUCTURAL
3F	4000 PSI CONC. DOCK PAVING RE. CIVIL FOR PAVING ELEVATIONS
3G	4000 PSI CONC. CURB RE. CIVIL
3H	PRECAST CONC. CAP
4	DIVISION 4: MASONRY & MASONRY PRODUCTS
4A	CONCRETE BLOCK BOND BEAM RE. STRUCTURAL FOR REIN.
4B	8" THK. SPLIT FACE CONC. BLOCK (PAINT) RE. ELEV. FOR COLOR OR 8" THK. SMOOTH CONC. B.L.K. WHERE NOTED FROM V.S.
4C	8" THK. SMOOTH CENTER SCORE COLOR CONC. BLOCK (PAINT) RE. ELEV. FOR COLORS
4D	NOT USED
4E	8" THK. SMOOTH FACED STANDARD COLOR BLOCK (PAINT), RE. ELEVATION FOR COLORS
4F	SMALLER STONE VENEER ON METAL LATHE
4G	NOT USED
4H	4" THK. SPLIT FACED CONC. BLOCK (PAINT) RE. ELEVATION FOR COLOR
4I	HORIZ. MASONRY REIN. RE. STRUCTURAL
4J	VERTICAL REINFORCEMENT IN GROUTED CELLS RE. STRUCTURAL
4K	14" DEEP BOND BEAM RE. ELEVATIONS FOR LOCATIONS
4L	GROUT FULL BELOW GRADE
4M	MASONRY VENEER ANCHORS AT 16" O.C. EA. MAX
4N	20 MIL. POLY FLASHING AND WEEPS AT 32" O.C.
5	DIVISION 5: STEEL & STEEL PRODUCTS
5A	STEEL TUBE RE. STRUCTURAL (PAINT EXPOSED AREAS)
5B	STEEL ROOF DECK RE. STRUCTURAL
5C	STEEL BAR JOIST RE.STRUCTURAL
5D	STEEL BEAM RE. STRUCTURAL
5E	STEEL BEAM / PLATE LATHE (PAINT)
5F	STEEL ANGLE RE. STRUCTURAL
5G	STEEL CHANNEL, RE. ELEVATIONS
5H	STEEL BENT PLATE RE. STRUCTURAL
5I	STEEL PLATE RE. STRUCTURAL
6	DIVISION 6: WOOD & WOOD PRODUCTS
6A	TREATED WOOD BLOCKING
6B	3/4" THK. TREATED PLYWOOD
6C	5/8" PLYWOOD ROOF DECKING
6D	1/2" EXTERIOR PLYWOOD SHEATHING WITH WEATHER RESISTANT MEMBRANE
6E	2x4 TREATED WOOD STUD @ 16" O.C.
7	DIVISION 7: THERMAL & MOISTURE PROTECTION
7A	PRE-FINISHED METAL CAP WITH CONTINUOUS CLIPS
7B	PRE-FINISHED METAL GUTTER & DOWNSPOUT
7C	PREFINISHED METAL FLASHING
7D	10 MIL. VAPOR BARRIER
7E	ROOF MEMBRANE
7F	ROOF MEMBRANE FLASHING, EXTEND UP PARAPET AND UNDER CAP WHERE SHOWN.
7G	ROOF INSULATION
7H	SMALLER STONE COMPOSITE SHINGLES ON 3/4" FELT, "DAMBER SLANT" BY TRADE OR APPROVED EQUAL
7I	2 1/4" E.L.F.S. AT GAP LOCATIONS
7J	4" X 3/4" E.L.F.S. PROTECTION
7K	EXPOSED E.L.F.S. CONTROL
7L	1 1/2" THK. E.L.F.S.
7M	3/4" E.L.F.S.
7N	LAP E.L.F.S. 1/4" AT CORNER FOR CONT. DRIP OR CARVE "Y" GROOVE DRIP
7O	BACK WRAP E.L.F.S. 1/2" FROM ADJACENT SURFACE INSTALL CLOSED CELL BACKER ROD AND SEAL (TYPICAL)
7P	CONT. 3" VENT IN ROOF FIBERGLASS SHEATHING, BACK WRAP E.L.F.S. AT AT VENT, SEAL, DGC AND PAINT VENT TO MATCH DRP.
7Q	FORMED INSULATION IN BLOCK CELLS
7R	SEAL ALL EXPOSED MASONRY TYPICAL WITH CLEAR SEALER
7S	FIBRE GAIT ON TREATED WOOD BLOCKING (ONLY REQUIRED F WOODED BRIMMER ROOF OFFER IS CHOSEN)
7T	6" R-19 FIBERGLASS INSULATION
7U	PREFINISHED STANDING SEAM METAL ROOFING ON 3/8" FELT
7V	PREFINISHED METAL DRIP
7W	WEATHER RESISTANT MEMBRANE WRAP
8	DIVISION 8: DOORS & WINDOWS
8A	ALUMINUM STOREFRONT
8B	AUTOMATIC DERRY PROXAGE
8C	SECTIONAL METAL OVERHEAD DOOR
9	DIVISION 9: FINISHES
9A	5/8" TYPE "X" GYP-SUM BOARD (PAINT)
9B	1/2" ROOF FIBERGLASS SHEATHING
9C	6" METAL STUDS AT 16" O.C.
9D	3 5/8" METAL STUDS AT 16" O.C.
9E	7/8" HD DIMENSION
9F	2 1/2" METAL STUDS AT 16" O.C.
9G	LAY-IN CEILING RE. REFLECTED CEILING PLAN
9H	METAL CORNER BEAD
9I	1/2" CEMENTIOUS BACKER BOARD FOR ALL TILE WALLS IN TOILET ROOMS.
9J	THE FINISH RE. FINISH SCHEDULE AND TOILET ROOM ELEVATIONS.
10	DIVISION 10: SPECIAL CONSTRUCTION
10A	DOWNLINE WALL PANELS SECURED TO HWY CHANNELS



NOTE: ALL SUBCONTRACTORS SHALL BE RESPONSIBLE FOR REVIEWING ALL DRAWINGS IN THE SET PRIOR TO PLACING BID.

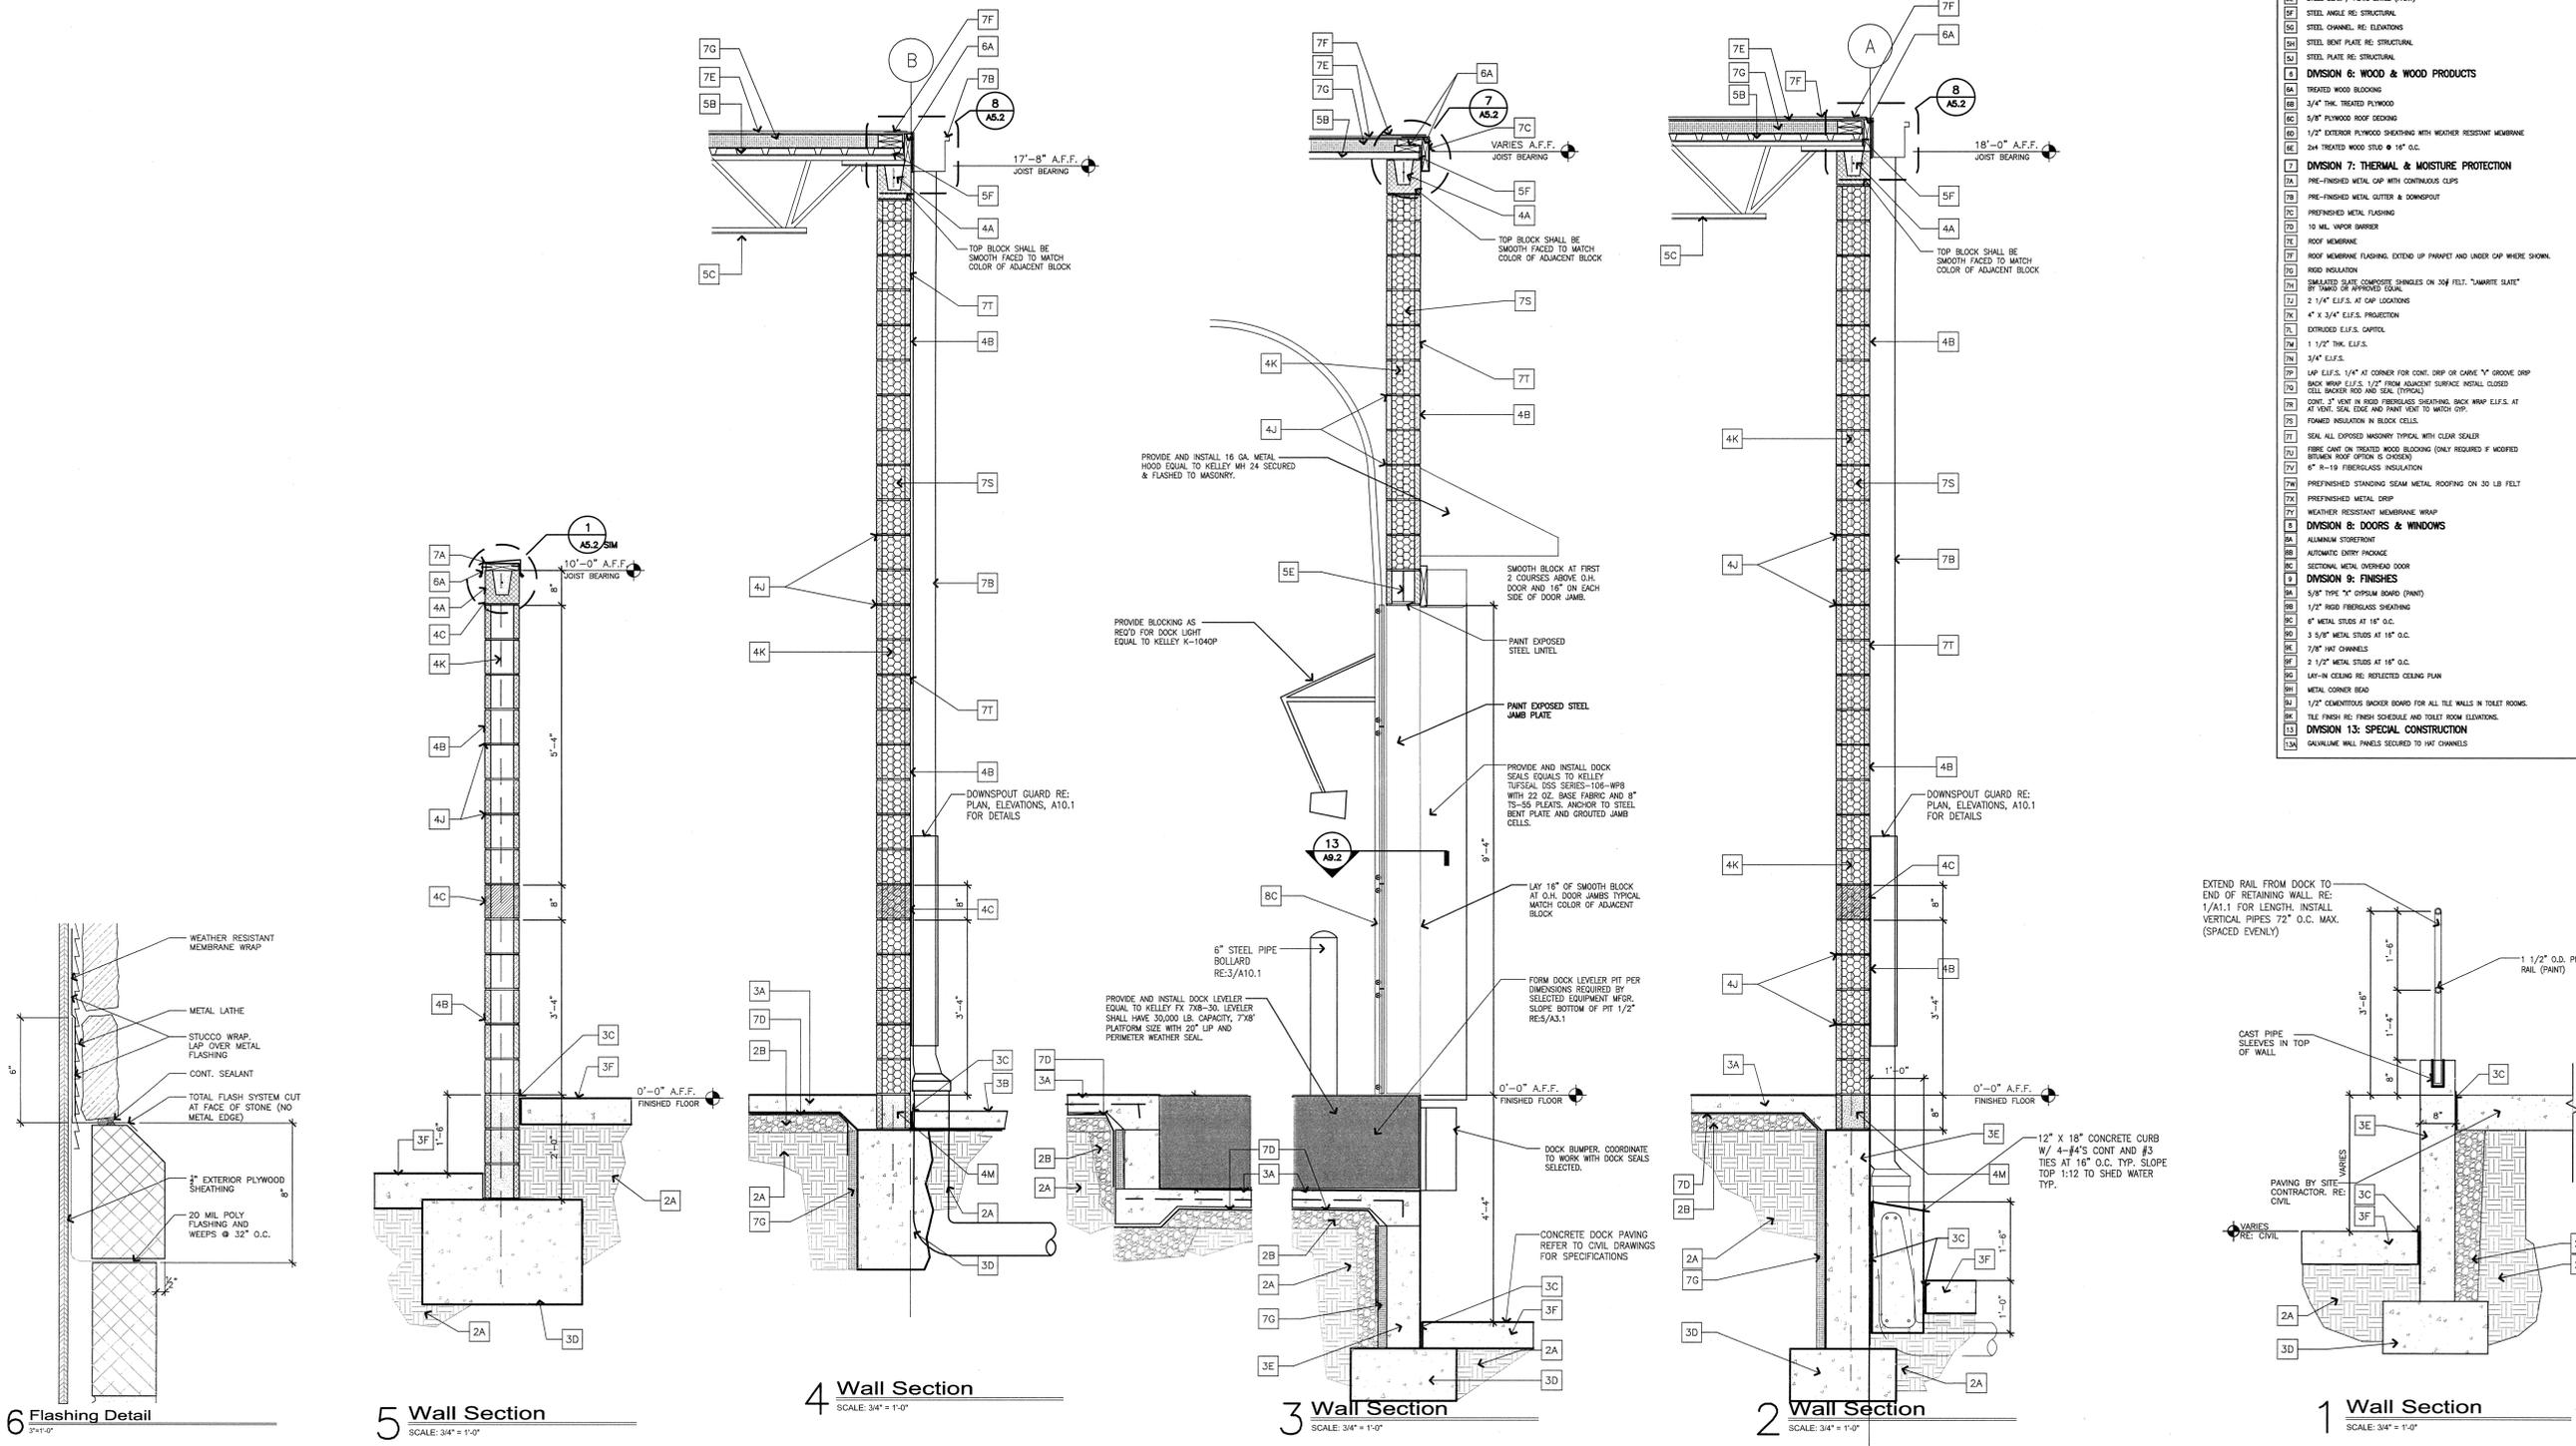

PERMIT SET


A New Grocery Facility for:  
**Harp's Food Stores** (Store # \_\_\_\_\_)  
 Corner of E. Highland Drive and Harrisburg Rd.  
 Jonesboro, Arkansas  
 © J. Price Architecture, Inc. 2011. All Rights Reserved




105 W Kansas  
 Suite C  
 Liberty, Missouri 64068  
 (816) 792-5991

REVISIONS:


EXTERIOR WALL SECTIONS  
 DATE: FEBRUARY 09, 2010  
 PROJECT: LIBERTY MISSOURI  
 SHEET NUMBER: **A7.4**

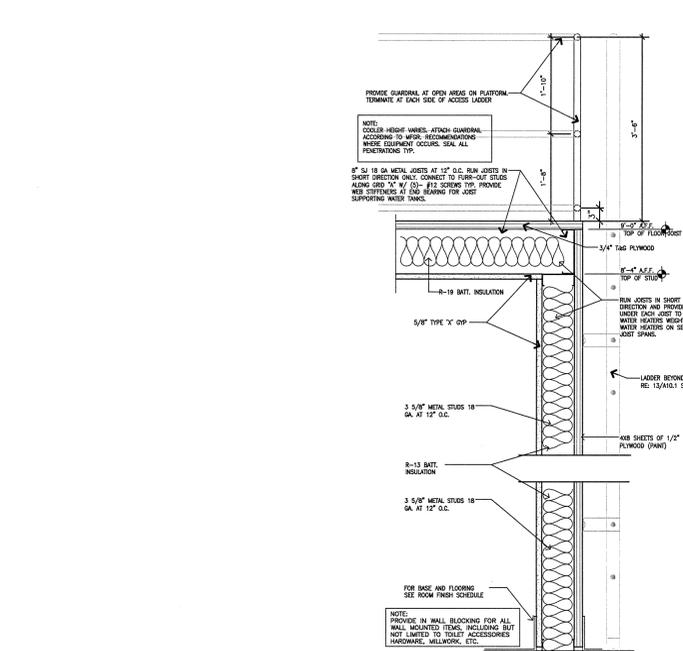


15 Interior Partition SCALE: N.T.S.

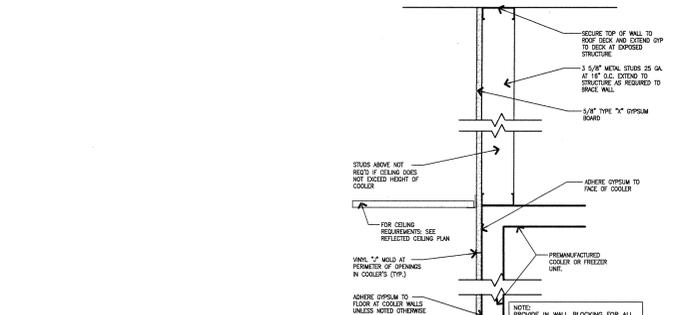


16 Furred Wall SCALE: N.T.S.

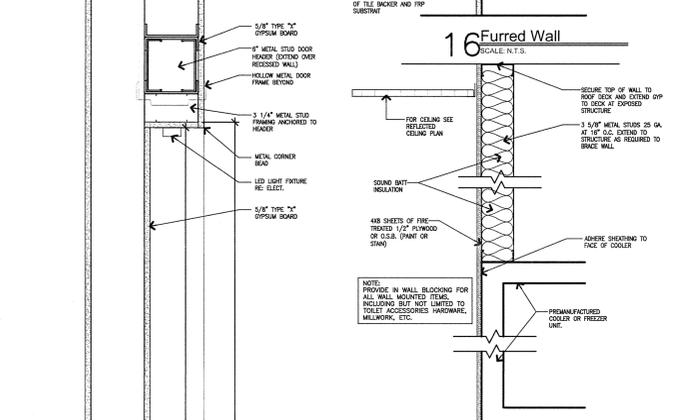


17 Furred Wall SCALE: N.T.S.

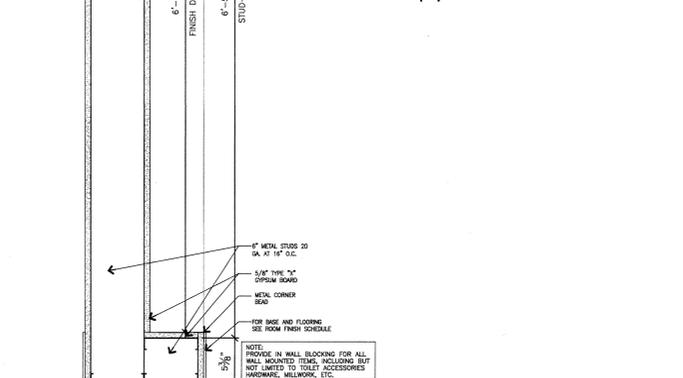


18 Interior Partition SCALE: N.T.S.

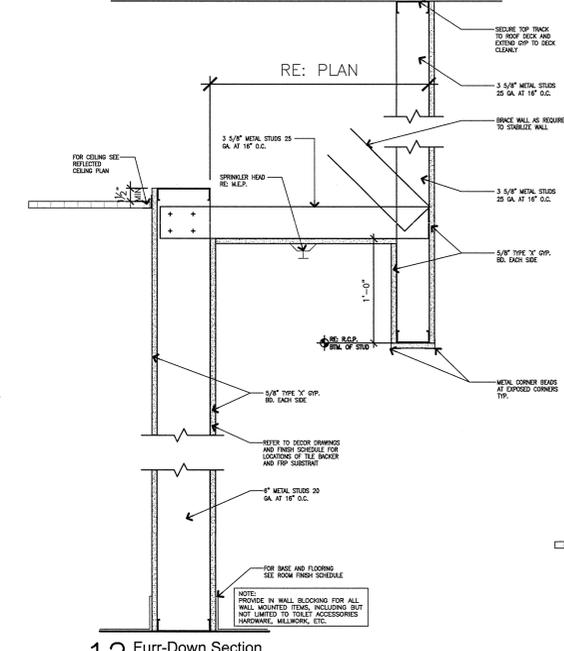


12 Furr-Down Section SCALE: N.T.S.

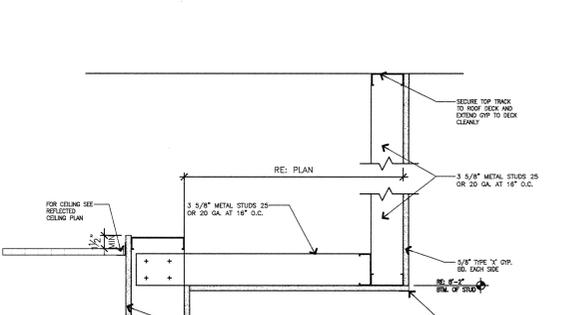


13 Furr Down Partition SCALE: N.T.S.

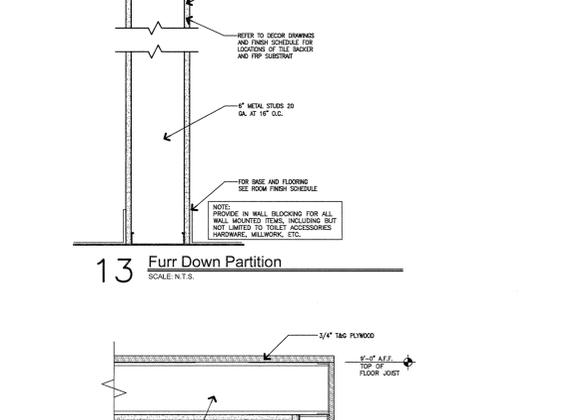


14 Partition Detail at Platform SCALE: N.T.S.

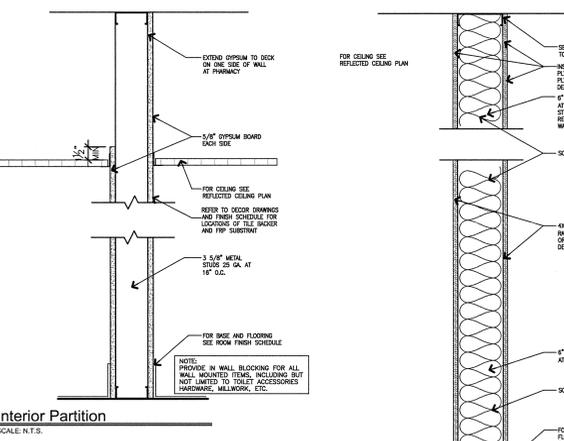


8 Interior Partition SCALE: N.T.S.

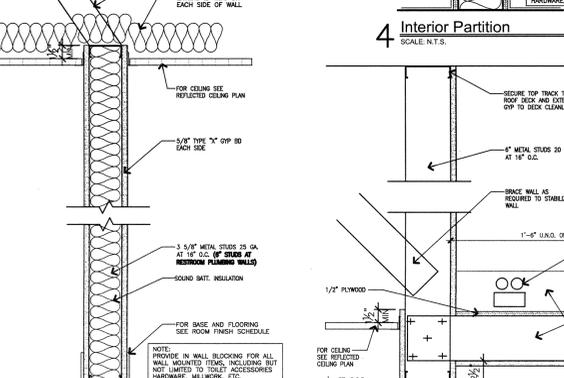

9 Interior Sound Partition SCALE: N.T.S.

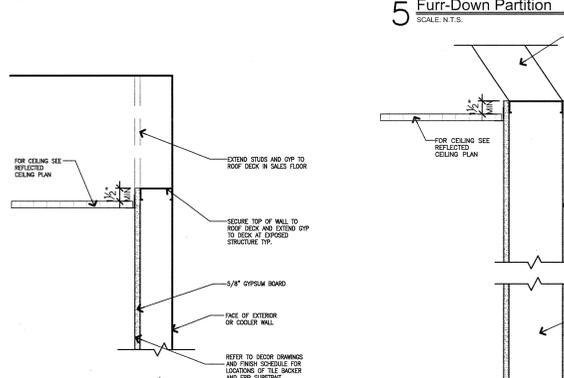


10 Interior Partition SCALE: N.T.S.

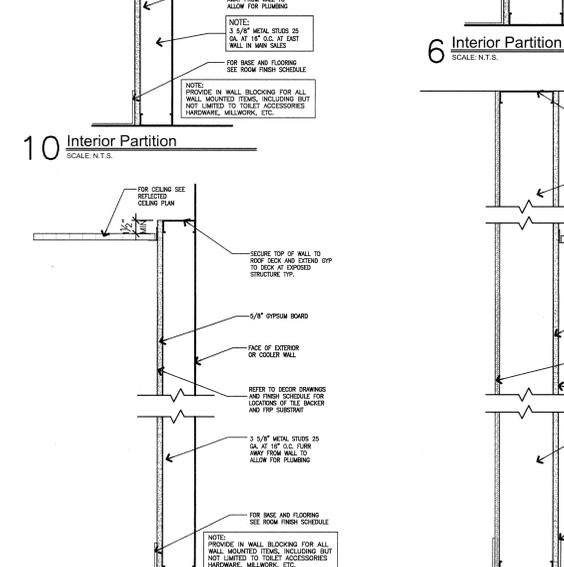


11 Interior Partition SCALE: N.T.S.

**PARTITION NOTES**


1. ALL STUD AND CHANNEL SPACING SHALL BE 16" UNLESS NOTED OTHERWISE.
2. UNSUPPORTED STUDS OVER 14'-0" TALL SHALL BE 20 GA.
3. LOCATE BRACING ON INTERIOR SIDE OF ROOM IN A CONCEALED MANNER.
4. WATER RESISTANT GYPSUM SHALL BE USED IN "WET" AREAS (TOILETS, FOOD PREP AREAS, ETC.)
5. BRACE TO ADJACENT WALLS WITH METAL STUDS WHERE POSSIBLE.
6. ALL DIMENSIONS ARE TO FACE OF METAL STUD UNLESS NOTED OTHERWISE.
7. MAXIMUM LENGTH OF UNBRACED WALL SHALL BE 8'-0".
8. REFER TO ROOM FINISH SCHEDULE FOR WALL FINISH MATERIALS.
9. INSTALL GREEN GYPSUM BOARD IN AREAS TO RECEIVE CERAMIC WALL TILE. RE: FINISH SCHEDULE AND INTERIOR ELEVATIONS FOR LOCATIONS.

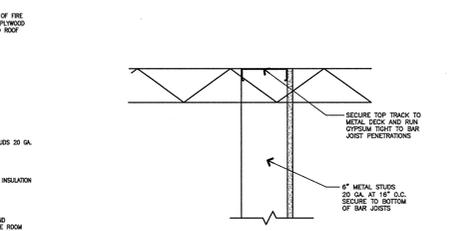


4 Interior Partition SCALE: N.T.S.

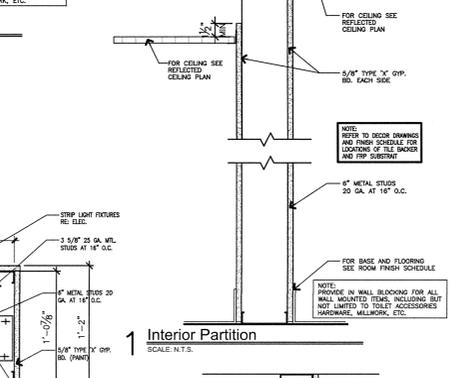

5 Furr-Down Partition SCALE: N.T.S.

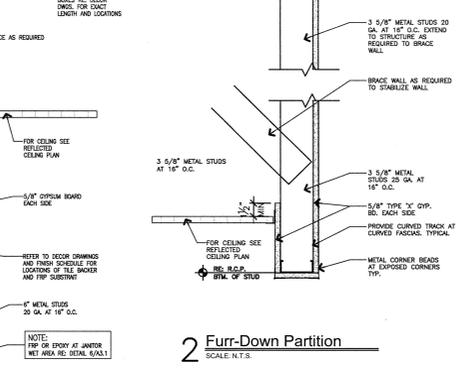


6 Interior Partition SCALE: N.T.S.

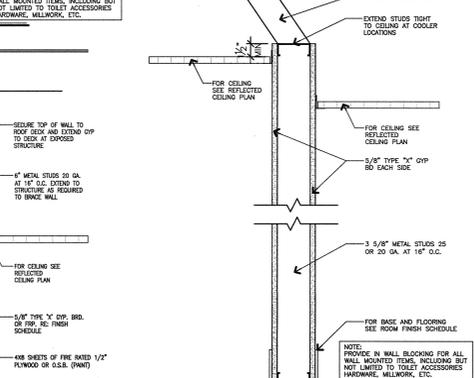

7 Interior Partition SCALE: N.T.S.



1 Interior Partition SCALE: N.T.S.

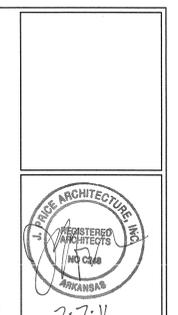


2-7-11

ALL SUBCONTRACTORS SHALL BE RESPONSIBLE FOR REVIEWING ALL DRAWINGS IN THE SET PRIOR TO PLACING BID.

**PERMIT SET**

A New Grocery Facility for:  
**Harp's Food Stores (Store # \_\_\_\_\_)**


Corner of E. Highland Drive and Harrisburg Rd.  
 Jonesboro, Arkansas  
 © J. Price Architecture, Inc. 2011 All Rights Reserved

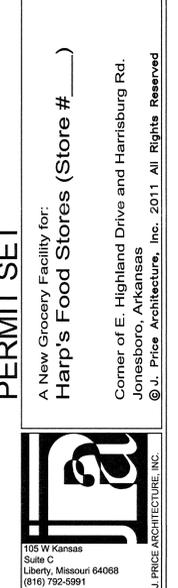






REVISIONS:

INTERIOR PARTITION SECTIONS  
 PROJECT: 10-0441  
 DATE: FEBRUARY 07, 2010  
 SHEET NUMBER: **A8.1**

DOOR AND STOREFRONT ELEVATIONS

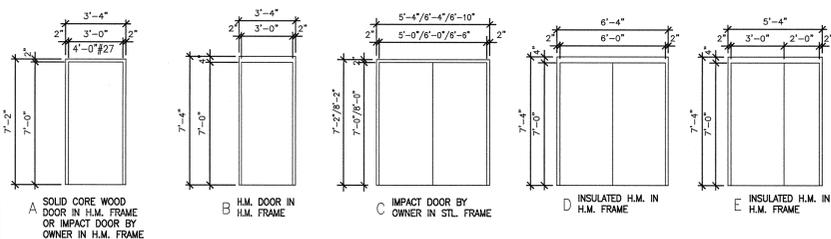

COORDINATE EXACT SIZE AND MOUNTING REQUIREMENTS WITH CHUTE SUPPLIER. PROVIDE INFORMATION TO GENERAL CONTRACTOR FOR PROPER SIZE OPENING AND SUPPORT IN WALL.

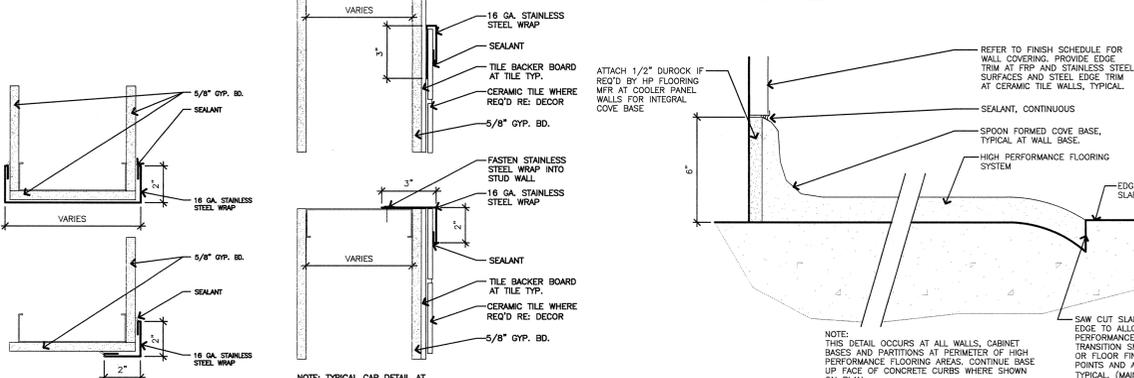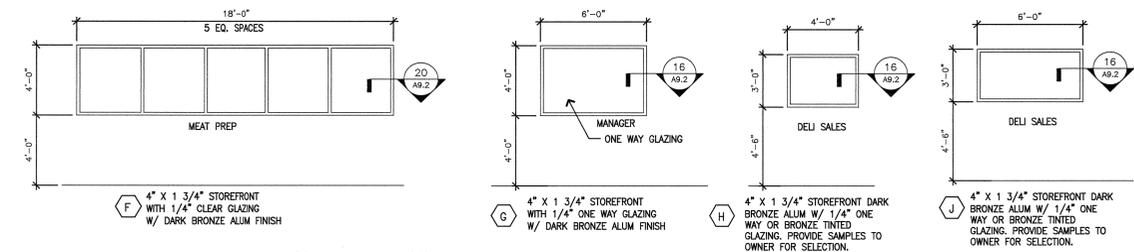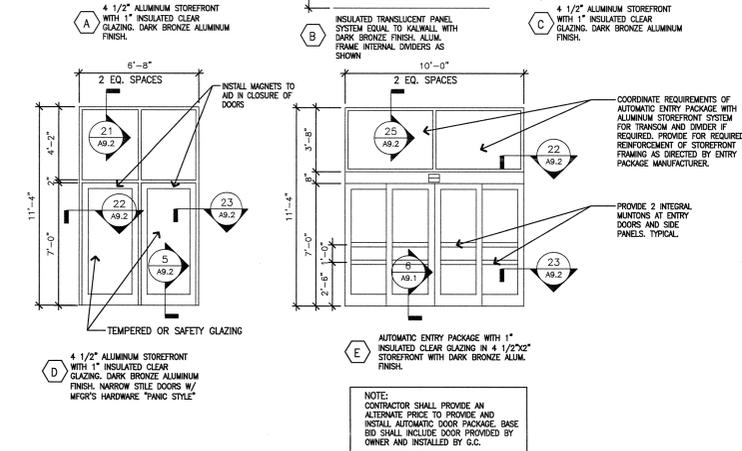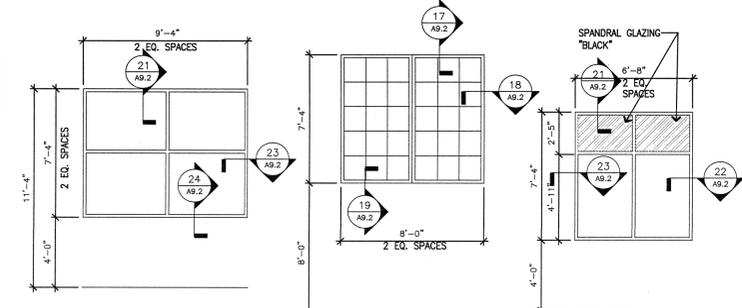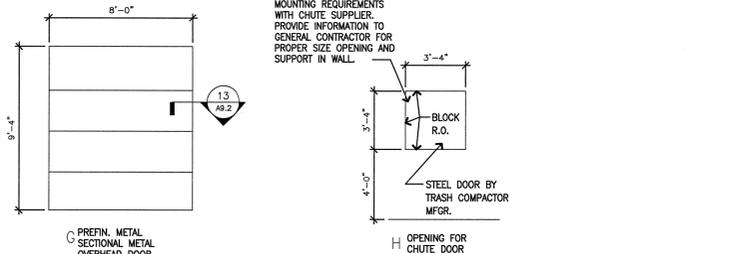

DOOR SCHEDULE










DOOR MARK	ROOM NUMBER	ROOM NAME	DOOR ELEV.			DOOR WIDTH	DOOR HEIGHT	DOOR THICKNESS	UL LABEL	DOOR TYPE	FRAME TYPE	HEAD CONDITION REAG.2 U.N.O.	JAMB CONDITION REAG.2 U.N.O.	ALTERNATE JAMB CONDITION REAG.2 U.N.O.	DOOR FINISH	FRAME FINISH	REMARKS
			ELEV.	WTH.	HGT.												
1	100	ENTRY	WIN. E	10'-0"	7'-0"	-	-	-	AL.	AL.	-	-	-	-	-	-	AUTOMATIC ENTRY PACKAGE
2	100	ENTRY	WIN. E	10'-0"	7'-0"	-	-	-	AL.	AL.	-	-	-	-	-	-	AUTOMATIC ENTRY PACKAGE
3	-	NOT USED															
4	101	SERVICE	A	3'-0"	7'-0"	1 3/4"	-	-	WD.	H.M.	1	2	4	-	-	-	
5	102	WOMEN	A	3'-0"	7'-0"	1 3/4"	-	-	WD.	H.M.	8	9	-	-	-	-	
6	103	MEN	A	3'-0"	7'-0"	1 3/4"	-	-	WD.	H.M.	1	2	4	-	-	-	
7	117	BREAK	A	3'-0"	7'-0"	1 3/4"	-	-	H.M.	6 SIM	2/AB.1	SIM.	-	-	-	-	FLUSH FRAME INSTALLED BY G.C.
8	105	CASH	A	3'-0"	7'-0"	1 3/4"	-	-	WD.	H.M.	8	9	4 SIM	-	-	-	COMBINATION DOOR LOCK AND PEEP VIEWER PROVIDED AND INSTALLED BY G.C.
9	106	MANAGER	A	3'-0"	7'-0"	1 3/4"	-	-	WD.	H.M.	1	2	4	-	-	-	
10	107	SPRINKLER	B	3'-0"	7'-0"	1 3/4"	-	-	H.M.	H.M.	11	12	-	14	-	-	
11	-	NOT USED															
12	130	SALES/BACKROOM	C	PAIR 3'-0"	8'-0"	-	-	-	STL.	6	7	-	-	-	-	-	IMPACT DOOR BY OWNER/ INSTALLED BY G.C. FRAME BY G.C.
13	108	DAIRY COOLER	-	5'-0"	7'-0"	-	-	-	-	-	-	-	-	-	-	-	DOOR BY COOLER MFR.
14	109	GROCERY FREEZER	-	5'-0"	7'-0"	-	-	-	-	-	-	-	-	-	-	-	DOOR BY FREEZER MFR.
15	111	SCAN	A	3'-0"	7'-0"	1 3/4"	-	-	WD.	H.M.	1	2	4	-	-	-	
16	112	ICE CREAM FREEZER	-	5'-0"	7'-0"	-	-	-	-	-	-	-	-	-	-	-	DOOR BY FREEZER MFR.
17	110	ELECTRICAL	E	PAIR 3'-0"	7'-0"	1 3/4"	-	-	H.M.	H.M.	8	9	-	-	-	-	PROVIDE PANIC BAR HARDWARE DEVICE-NO ALARM
18	115	TRASH (COORDINATE)	H	3'-4"	3'-4"	-	-	-	STL.	-	-	-	-	-	-	-	DOOR AND FRAME BY COMPACTOR MFR. COORDINATE CONDITIONS.
19	115	BACKROOM	D	PAIR 3'-0"	7'-0"	-	-	-	HM	HM	11	12	-	14	-	-	SERVES AS EMERGENCY EXIT AS WELL TYP. PANIC DEVICE W/ ALARM & DETEX KEY
20	115	BACKRM/LOADING	G	8'-0"	9'-4"	-	-	-	MTL	MTL	13	13	-	-	-	-	SECTIONAL OVERHEAD DOOR
21	113	MEAT COOLER	-	5'-0"	7'-0"	-	-	-	-	-	-	-	-	-	-	-	DOOR BY COOLER MFR.
22	114	MEAT PREP	-	PAIR 3'-0"	7'-0"	-	-	-	-	-	-	-	-	-	-	-	DOOR BY COOLER MFR.
23	114	MEAT PREP	-	3'-0"	7'-0"	-	-	-	-	-	-	-	-	-	-	-	DOOR BY COOLER MFR.
24	114	MEAT PREP/SALES	-	3'-0"	7'-0"	-	-	-	-	-	3/AB.1	-	-	-	-	-	DOOR BY COOLER MFR.
25	116	DEPARTMENT MANAGER	A	3'-0"	7'-0"	1 3/4"	-	-	WD.	H.M.	8	9	-	-	-	-	
26	119	RESTROOM	A	3'-0"	7'-0"	1 3/4"	-	-	WD.	H.M.	1	2	3	-	-	-	
27	118	JANITOR	A	4'-0"	7'-0"	1 3/4"	-	-	FRAME ONLY	H.M.	6 SIM	2/AB.1	SIM.	-	-	-	FLUSH FRAME INSTALLED BY G.C.
28	121	PRODUCE PREP	-	6'-0"	7'-0"	1 3/4"	-	-	FRAME ONLY	STL.	6 SIM	7 SIM	-	-	-	-	STEEL FRAME BY G.C. INSTALLED BY G.C.
29	120	PRODUCE COOLER	-	PAIR 2'-8"	8'-0"	-	-	-	-	-	-	-	-	-	-	-	DOOR BY COOLER MFR.
30	130	SALES/BACKRM	C	PAIR 3'-0"	8'-0"	-	-	-	STL.	6	7	-	-	-	-	-	IMPACT DOOR BY OWNER/ INSTALLED BY G.C. FRAME BY G.C.
31	130	SALES	B	3'-0"	7'-0"	1 3/4"	-	-	HM.	H.M.	11	12	-	5	-	-	SERVES AS EMERGENCY EXIT AS WELL TYP. PANIC DEVICE W/ ALARM & DETEX KEY
32	122	GAS MECHANICAL	A	3'-0"	7'-0"	1 3/4"	-	-	WD.	H.M.	1	2	4	-	-	-	
33	125	FREEZER	-	3'-0"	7'-0"	-	-	-	-	-	-	-	-	-	-	-	DOOR BY FREEZER MFR./ INSTALLED BY R.C.
34	126	COOLER	-	3'-0"	7'-0"	-	-	-	-	-	-	-	-	-	-	-	DOOR BY COOLER MFR./ INSTALLED BY R.C.
35	128	DRINK BAR	WIN. D	(2)3'-0"	7'-0"	-	-	-	AL.	AL.	-	-	-	5	-	-	ALUMINUM STOREFRONT DOORS. INSTALL MAGNETS
36	132	BAKERY CLOSET	A	3'-0"	7'-0"	1 3/4"	-	-	WD.	H.M.	1	2	4	-	-	-	
37	133	STORAGE	A	3'-0"	7'-0"	1 3/4"	-	-	WD.	H.M.	1	2	4	-	-	-	

NOTE: DOOR CLOSER HARDWARE SHOULD BE SET AT 5 LBS MAXIMUM TO MAINTAIN ADA CODE TYPICAL.

FINISH SCHEDULE

ROOM NUMBER	ROOM NAME	FLOOR FINISH	WALL FINISH	CEILING FINISH	DOOR FINISH	CEILING HEIGHT	REMARKS
100	ENTRY	WC (SEE NOTE BELOW)	GP/GLASS	R/CONC.	L1	12'-8"	INSTALL HOLD DOWN CLIPS IN GLG.
101	SERVICE	PC	GP	R	L1	11'-4"	
102	WOMEN	PC	CT	CT	GYP	9'-0"	
103	MEN	PC	CT	CT	GYP	9'-0"	
104	HALL	PC	GP	R	L1	8'-3"	
105	CASH	PC	GP	R	L1	8'-0"	
106	MANAGER	PC	GP	R	L1	8'-6"	
107	SPRINKLER	SC	PLYWD/MAS	-	EX	-	
108	DAIRY COOLER	SC	-	-	-	-	PREFAB. COOLER
109	GROCERY FREEZER	SC	-	-	-	-	PREFAB. FREEZER
110	ELECTRICAL	SC	PLYWOOD/MAS	-	EX	-	NO PAINT REQUIRED
111	SCAN	SC	GP	R	GYP	8'-6"	
112	FREEZER	SC	-	-	-	-	PREFAB. FREEZER
113	MEAT COOLER	SC	-	-	-	-	PREFAB. COOLER
114	MEAT PREP	EP	-	EP	-	-	PREFAB. COOLER EPOXY FLOOR FINISH IS "DURA-FLEX" 028-30 OR DESCO DB 108
115	BACKROOM	SC	PLYWD/COOLER/MAS	NONE	EX	-	NO PAINT REQUIRED
116	DEPARTMENT MANAGER	SC	GP	R	L1	9'-0"	
117	BREAK	SC	GP	R	L1	9'-0"	
118	JANITOR	EP	FRP	EP	L1	8'-0"	FRP ENTIRE AREA EPOXY FLOOR FINISH IS "DURA-FLEX" 028-30 OR DESCO DB 108
119	RESTROOM	SC	GP	R	L1	8'-0"	
120	PRODUCE COOLER	SC	-	-	-	-	PREFAB. COOLER
121	PRODUCE PREP	SC	FRP	R	L2	9'-0"	
122	GAS MECHANICAL	SC	GP	R	L1	8'-0"	
123	DELI/BAKERY	EP	FRP	EP	L2	9'-0"	EPOXY FLOOR FINISH IS "DURA-FLEX" 028-30 OR DESCO SYSTEMS DB 108
124	DELI SALES	EP	CT	EP	L2	9'-0"	EPOXY FLOOR FINISH IS "DURA-FLEX" 028-30 OR DESCO SYSTEMS DB 108
125	FREEZER	SC	-	-	-	-	PREFAB. FREEZER
126	COOLER	SC	-	-	-	-	PREFAB. COOLER
127	GAS	EP	CT	R	L1	9'-0"	EPOXY FLOOR FINISH IS "DURA-FLEX" 028-30 OR DESCO SYSTEMS DB 108
128	DRINK BAR	PC	GP	R	L1	12'-8"	
129	CARTS	WC	GP/GLASS	R/CONC.	L1	12'-8"	INSTALL HOLD DOWN CLIPS IN GLG.
130	SALES	PC	GP	R	EX	-	REDECOR DRAWINGS FOR FLOOR PATTERNS
131	CHECKOUT	PC	GP	R	EX	-	REDECOR DRAWINGS FOR FLOOR PATTERNS
132	BAKERY CLOSET	EP	FRP	EP	L1	8'-0"	EPOXY FLOOR FINISH IS "DURA-FLEX" 028-30 OR DESCO SYSTEMS DB 108
133	STORAGE	PC	GP	R	L1	11'-4"	
134	HALL	PC	GP	R	L1	11'-4"	

NOTE: WALK OFF CARPET AT ENTRY VESTIBULE SHALL BE "BRUNO" BY SBEMCO INTERNATIONAL. CUSTOM FLOOR MATTING-#25 PUMICE. RECESS SLAB 3/8" IN VESTIBULE TO RECEIVE FLOOR SYSTEM. CONTACT SBEMCO INTERNATIONAL, INC. (800) 468-0860 FOR INSTALLATION INSTRUCTIONS.

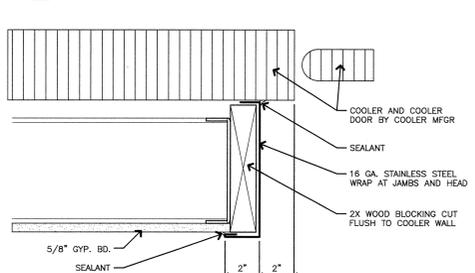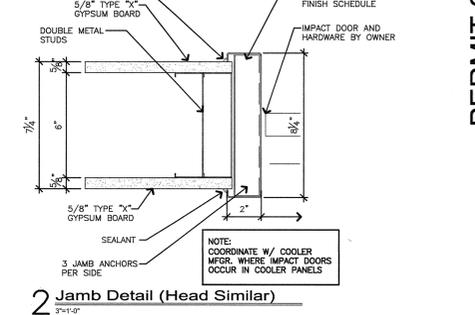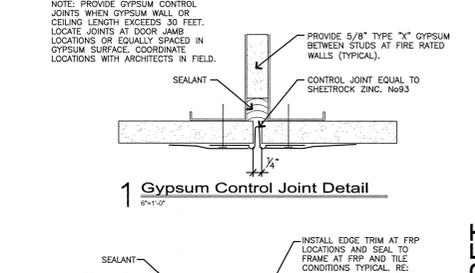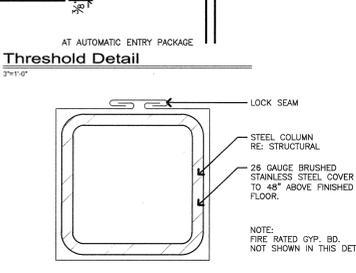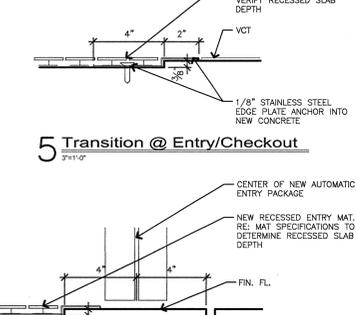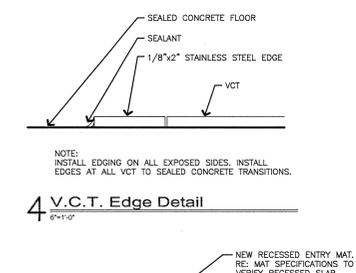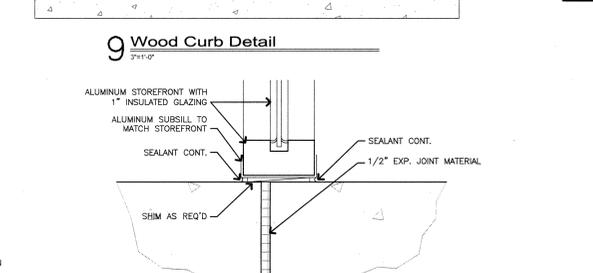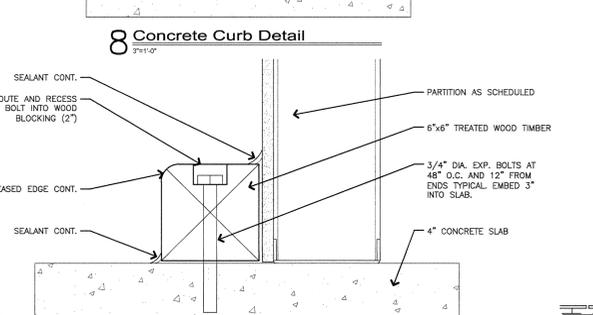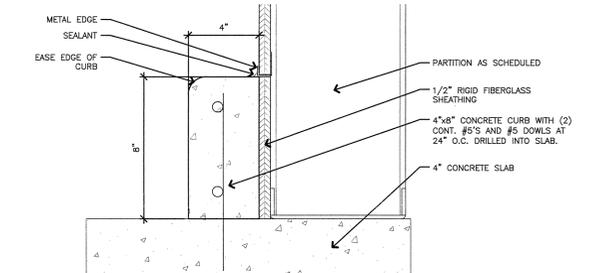

ALL SUBCONTRACTORS SHALL BE RESPONSIBLE FOR REVIEWING ALL DRAWINGS IN THE SET PRIOR TO PLACING BID.


PERMIT SET  
A New Grocery Facility for:  
**Harp's Food Stores (Store # )**  
Corner of E. Highland Drive and Harrisburg Rd.  
Jonesboro, Arkansas  
© J. Price Architecture, Inc. 2011 All Rights Reserved




103 W Kansas  
Suite C  
Liberty, Missouri 64068  
(816) 752-5991

REVISIONS:


DOOR AND FINISH SCHEDULE  
DATE: FEBRUARY 02, 2010  
PROJECT: A9.1  
SHEET NUMBER: A9.1

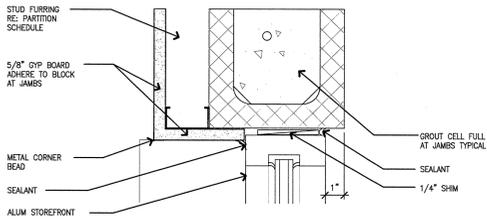


23 Jamb Detail

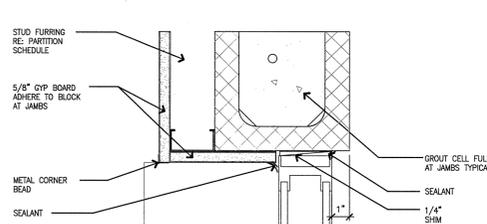


18 Jamb Detail

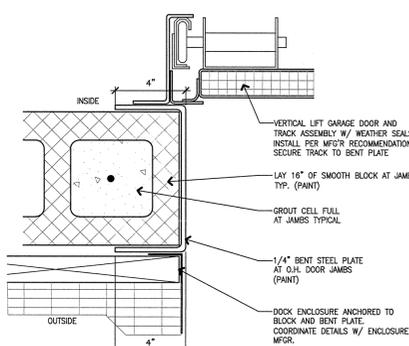


13 Jamb @ O.H. Door

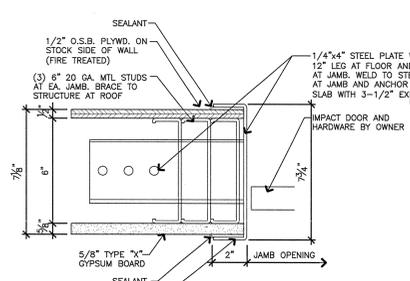


7 Jamb @ Impact Door

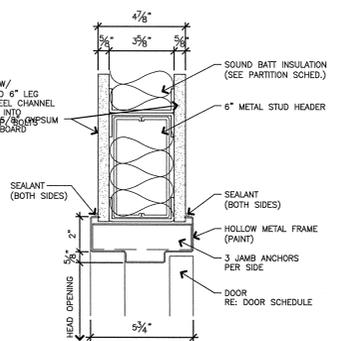


1 Door Head @ 3-5/8\"/>

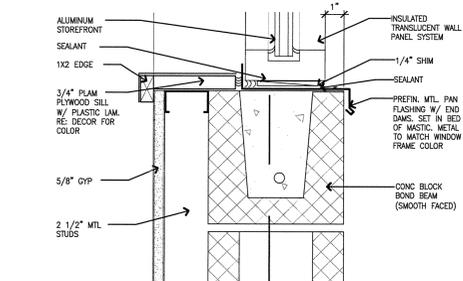


24 Sill Detail

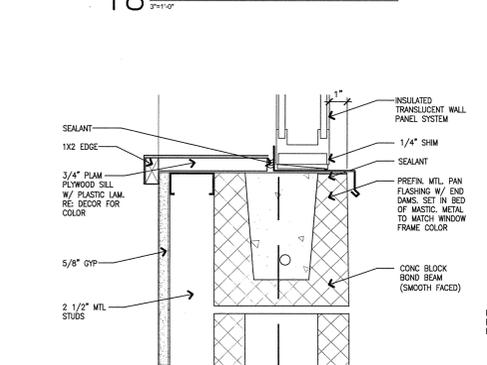


19 Sill Detail

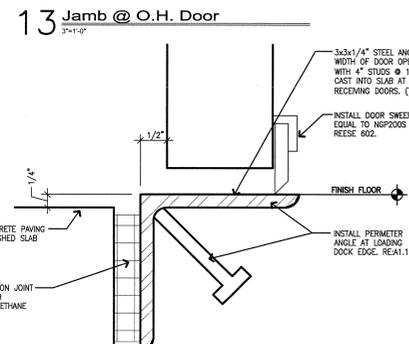


14 Threshold Detail

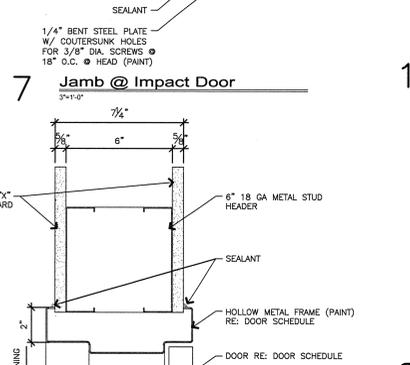


8 Door Head @ 6\"/>

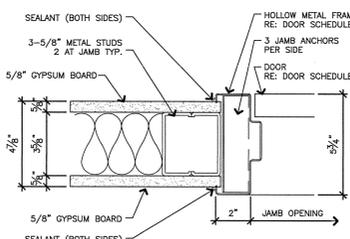


2 Door Jamb @ 3-5/8\"/>

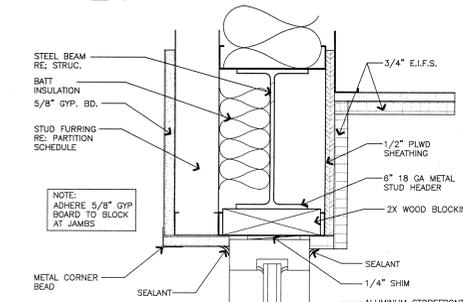


25 Head Detail

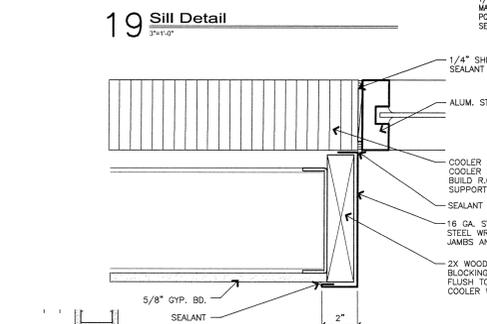


20 Jamb Detail (Head & Sill Sim.)

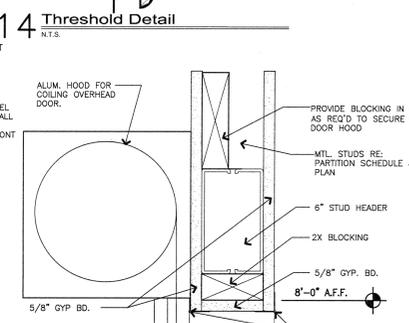


15 Head Detail @ Coiling Door

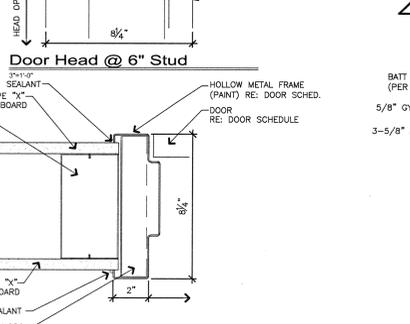


9 Door Jamb @ 6\"/>

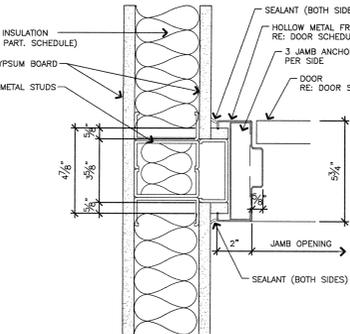


3 Door Jamb @ 3-5/8\"/>

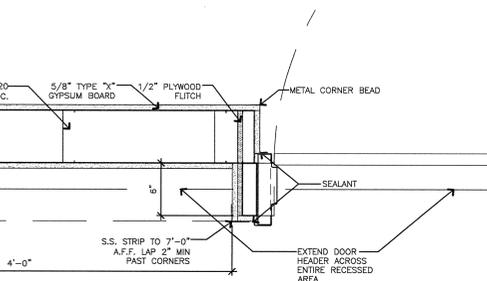


26 Plan @ Service Area Recess Wall

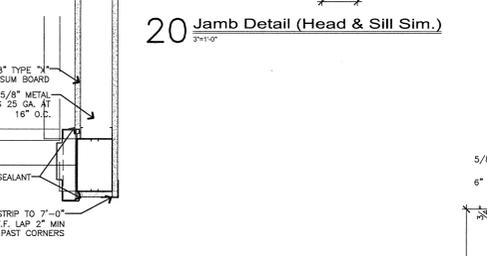

16 Jamb Detail (Head Sim.)

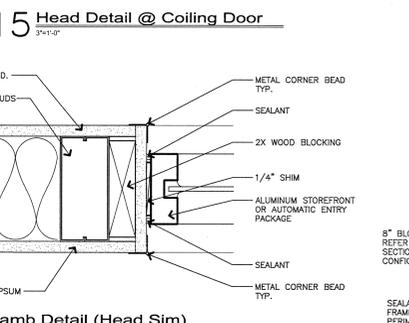


10 Jamb Detail @ Coiling Door

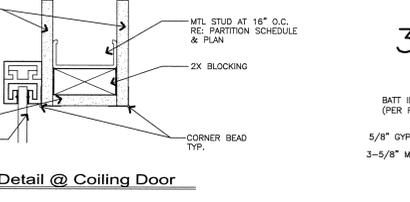


4 Door Jamb @ 3-5/8\"/>




21 Head Detail

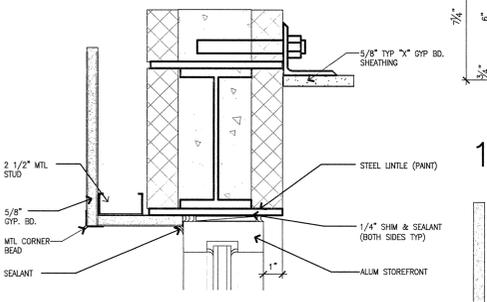


17 Head Detail

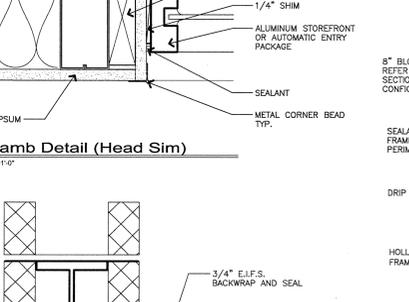

11 Door Head @ Block

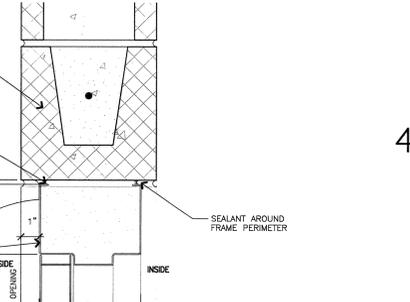


5 Threshold Detail

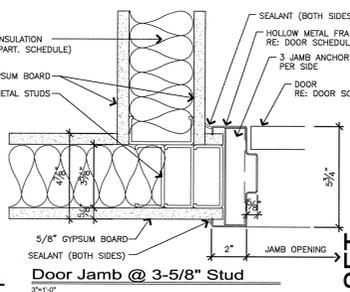


6 Head @ Impact Door



22 Jamb Detail

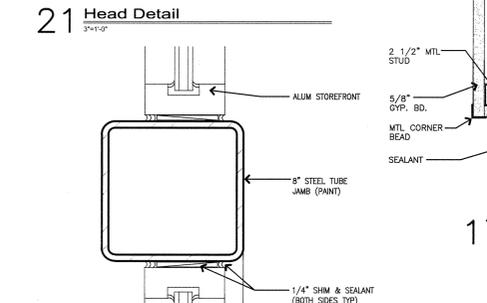

12 Door Jamb @ Block

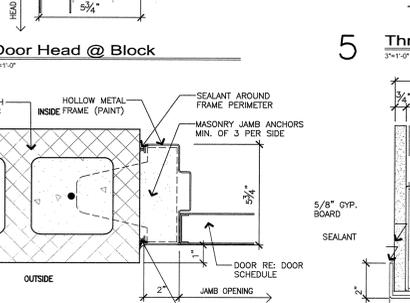

6 Head @ Impact Door



NOTE: ALL SUBCONTRACTORS SHALL BE RESPONSIBLE FOR REVIEWING ALL DRAWINGS IN THE SET PRIOR TO PLACING BID.


PERMIT SET  
A New Grocery Facility for:  
**Harp's Food Stores (Store # \_\_\_\_\_)**  
Corner of E. Highland Drive and Harrisburg Rd.  
Jonesboro, Arkansas  
© J. Price Architecture, Inc. 2011. All Rights Reserved.




105 W Kansas  
Suite C  
Liberty, Missouri 64068  
(816) 792-5991

REVISIONS:

PROJECT: DATE: SHEET NUMBER:  
A9.2

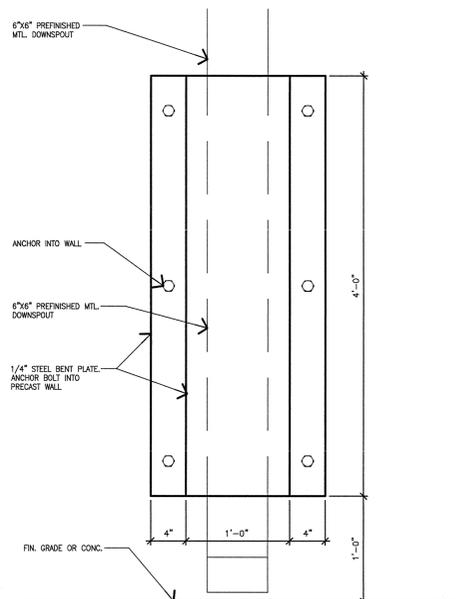


ELEVATION

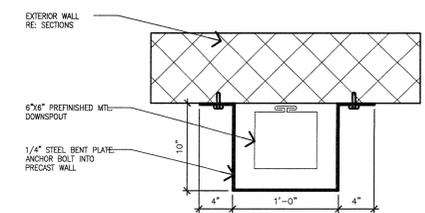


PLAN

14 Plan Detail (Downspout Guard)  
SCALE: 1-1/2" = 1'-0"

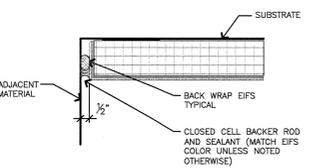


NOTE: INSTALL EXPANSION JOINT SHOWN HERE AT ALL LOCATIONS WHERE EPS TERMINATES TYPICAL (WALLS AND SOFFITS)


15 E.I.F.S. Termination at Dissimilar Material  
SCALE: 3" = 1'-0"

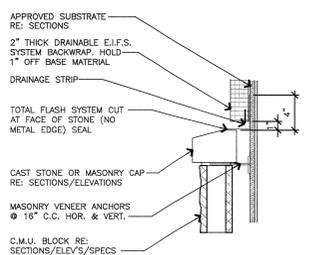


16 E.I.F.S. Termination at Cap Detail  
SCALE: 1 1/2" = 1'-0"

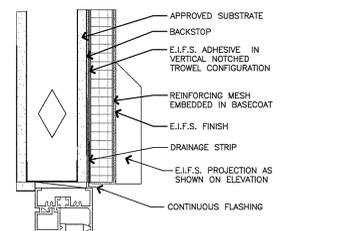


11 E.I.F.S. Detail at Window with Drainage Strip  
SCALE: N.T.S.

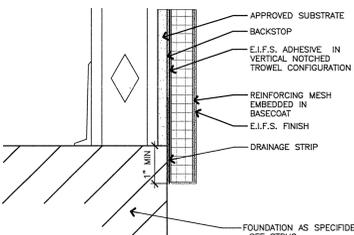

12 Foundation with Drainage Strip  
SCALE: N.T.S.

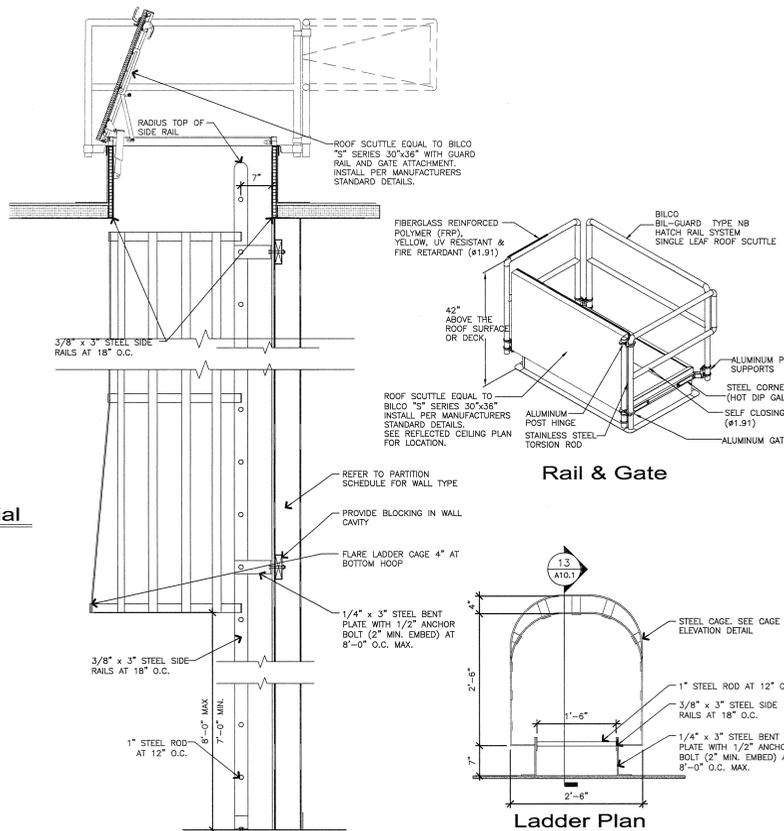


13 Roof Access Ladder Details  
3/4" = 1'-0"

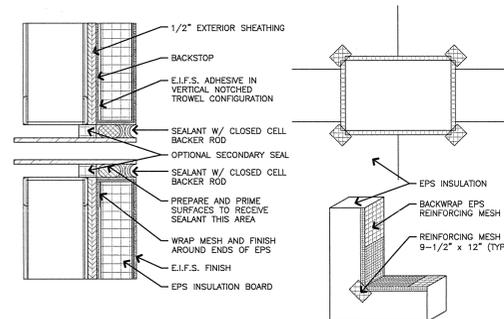


6 E.I.F.S. Penetration Detail  
3/4" = 1'-0"

NOTE:


- IT IS RECOMMENDED THAT GROUND FLOOR APPLICATIONS AND ALL FACADES EXPOSE TO ABNORMAL STRESS, HIGH TRAFFIC, OR DELIBERATE IMPACT HAVE THE BASE COAT REINFORCED WITH HEAVY DUTY MESH PRIOR TO A STANDARD BASE MESH. LOCATION OF HIGH IMPACT ZONES SHOULD BE INDICATED ON CONTRACT DRAWINGS.
- DOUBLE WRAP OUTSIDE CORNERS WITH REINFORCED MESH OR USE CORNER MESH.
- DO NOT LAP REINFORCING MESH WITH IN 8" OF A CORNER.

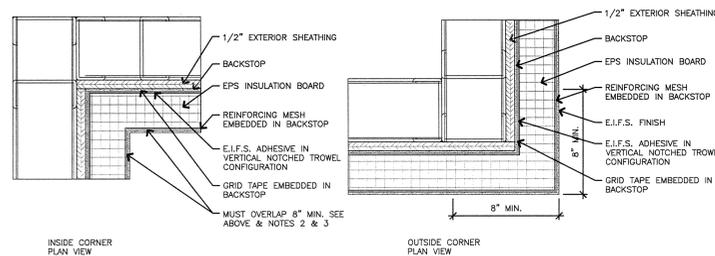


7 E.I.F.S. Typ Corner Detail  
3/4" = 1'-0"

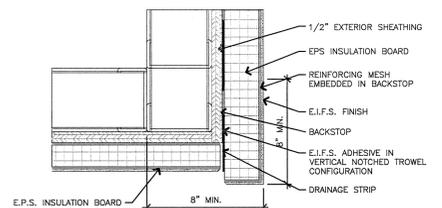


8 E.I.F.S. Soffit Edge Detail  
3/4" = 1'-0"

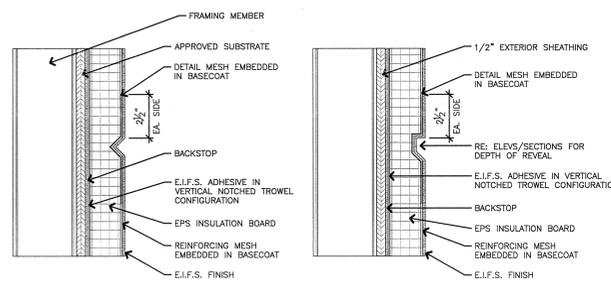


9 E.I.F.S. Reveal Detail  
3/4" = 1'-0"

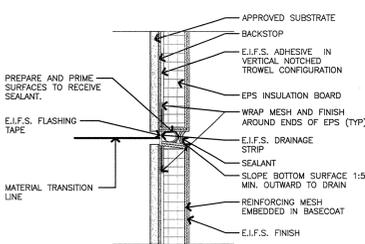


10 E.I.F.S. Detail At Expansion Joint  
SCALE: N.T.S.

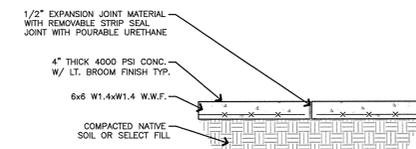


1 Typ. Sidewalk Expansion Joint  
3/4" = 1'-0"

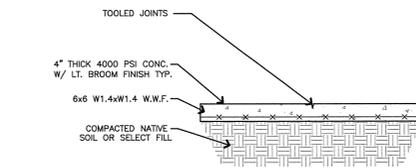


2 Typ. Sidewalk Control Joint  
3/4" = 1'-0"

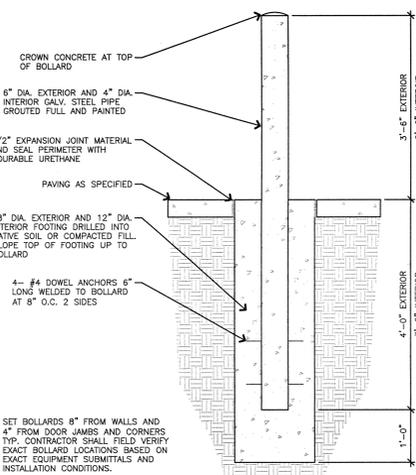

3 Bollard Detail  
3/4" = 1'-0"

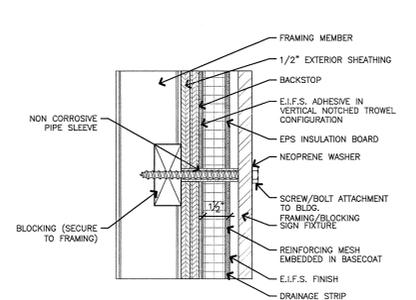

4 E.I.F.S. Sign Attachment Detail  
3/4" = 1'-0"

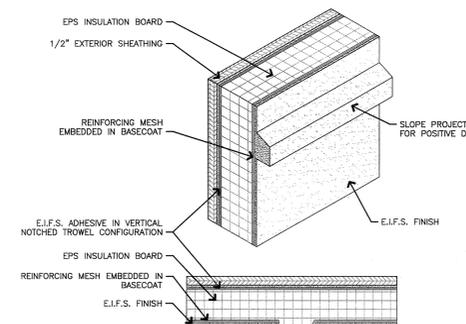

5 E.I.F.S. Projection Detail  
NTS



NOTE: SUBCONTRACTORS SHALL BE RESPONSIBLE FOR OBTAINING ALL PERMITS AND SET PLACING BIDDING.

PERMIT SET

A New Grocery Facility for:  
**Harp's Food Stores (Store # )**  
Corner of E. Highland Drive and Harrisburg Rd.  
Jonesboro, Arkansas  
© J. Price Architecture, Inc. 2011. All Rights Reserved



105 W Kansas  
Suite C  
Liberty, Missouri 64068  
(816) 792-5991

REVISIONS:

SITE E.I.F.S. AND MISCELLANEOUS DETAILS  
PROJECT: FEBRUARY 02, 2010  
SHEET NUMBER: A10.1