


COPYRIGHT © 2020 CRIST ENGINEERS, INC.

NAME	OWNER	APPLICANT
JONESBORO CITY, WATER & LIGHT	JONESBORO CITY, WATER & LIGHT	JONESBORO CITY, WATER & LIGHT
ADDRESS	400 E MONROE AVE.	400 E MONROE AVE.
PHONE NUMBER	870-930-3300	870-930-3300

SUBDIVISION	RIDGECREST ADDITION
IMPERVIOUS SURFACE RATIO	21.90%
ZONING CLASSIFICATION	R1 RESIDENTIAL



**PROJECT LOCATION**  
N.T.S.

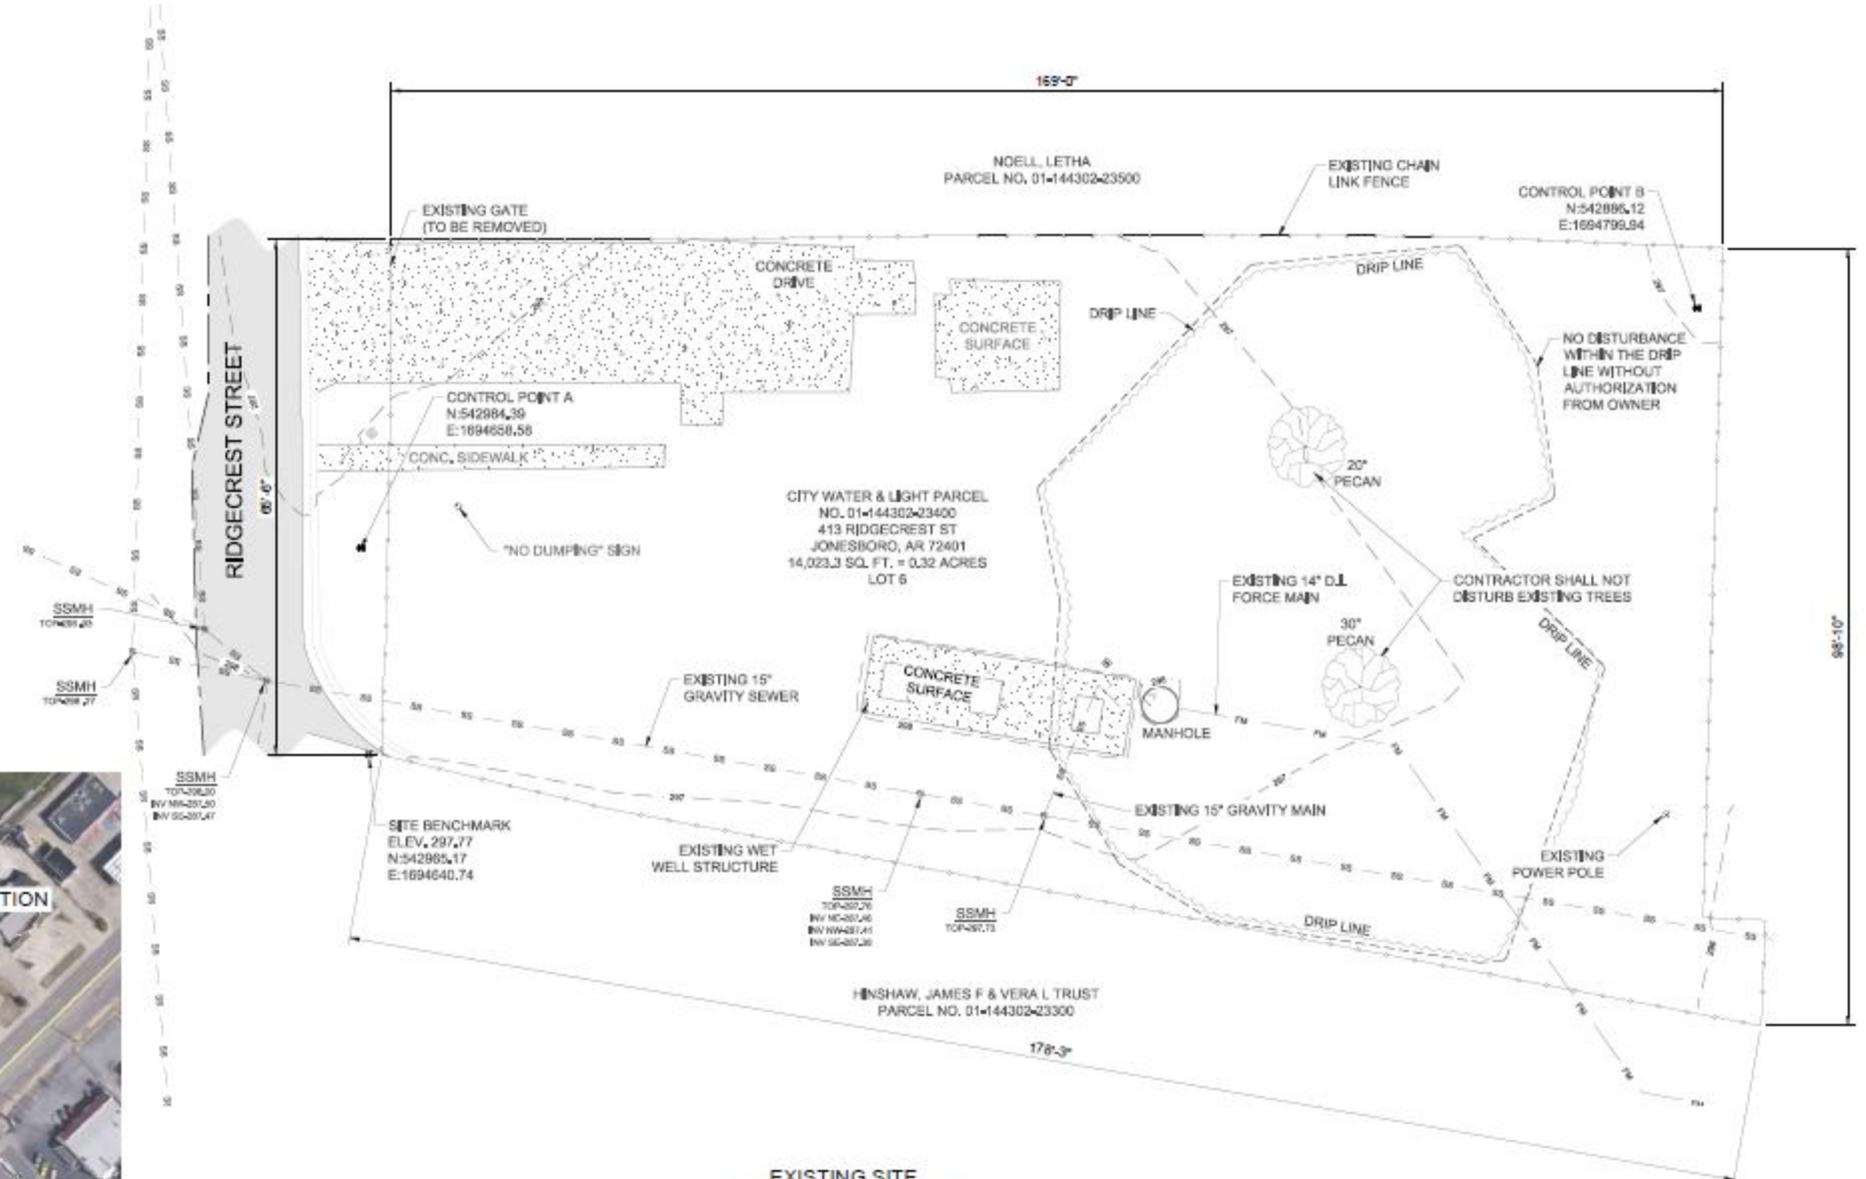

**EXISTING SITE PLAN**  
SCALE = 1" = 10'

- NOTES:**
1. LOCATION OF EXISTING UTILITIES IS REFERENCED FROM AS-BUILT AND GIS INFORMATION. LOCATION OF UNDERGROUND UTILITIES IS NOT GUARANTEED ACCURATE OR ALL INCLUSIVE. CONTRACTOR IS RESPONSIBLE FOR MAKING HIS OWN DETERMINATION AS TO WHETHER HIS ACTIVITIES IMPOSE A RISK TO THE EXISTING UTILITIES TO AVOID DAMAGE THERETO. CONTRACTOR SHALL LOCATE AND POTHOLE TO LOCATE UNDERGROUND UTILITIES TO DETERMINE ELEVATIONS WHERE POTENTIAL CONFLICTS ARE APPARENT.
  2. THIS PROJECT IS WITHIN DESIGNATED SPECIAL FLOOD HAZARD AREA, ZONE AE REGULATORY FLOODWAY AS SHOWN ON PRELIMINARY FEMA FIRM PANEL NO.: 05031C0254D DATED 06/30/2020.

REV. NO.	DATE	DRWN	CHKD	REMARKS



THIS LINE MEASURES 1" WHEN PLOTTED FULL SIZE

DESIGNED: CAJ  
DRAFTED: MAB/PPH  
CHECKED: CAJ  
DATE: NOV 2020



**CRIST ENGINEERS, INC.**  
CONSULTING ENGINEERS  
205 EXECUTIVE COURT  
LITTLE ROCK, ARKANSAS 72205  
TELEPHONE: (501) 694-1582  
FAX: (501) 664-8079  
WWW.CRISTENGINEERS.COM

JONESBORO CITY, WATER & LIGHT  
**WASTEWATER IMPROVEMENTS  
RIDGECREST SEWER LIFT STATION**  
BID SET  
EXISTING SITE PLAN

JOB NO. 1972  
SHEET NO. C-2

P: 2019 P:\Jobs\1972 - CIVIL - Ridgecrest Sewer Lift Station - CAD\02 - CIVIL\1972 - Ridgecrest Sewer Lift Station.dwg